
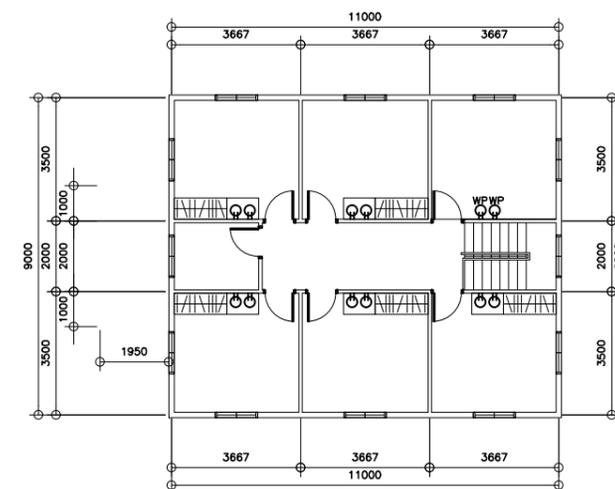


LEGEND	
	DUPLEX CONVENIENCE OUTLET
	WEATHERPROOF DUPLEX CONVENIENCE OUTLET
	PANELBOARD


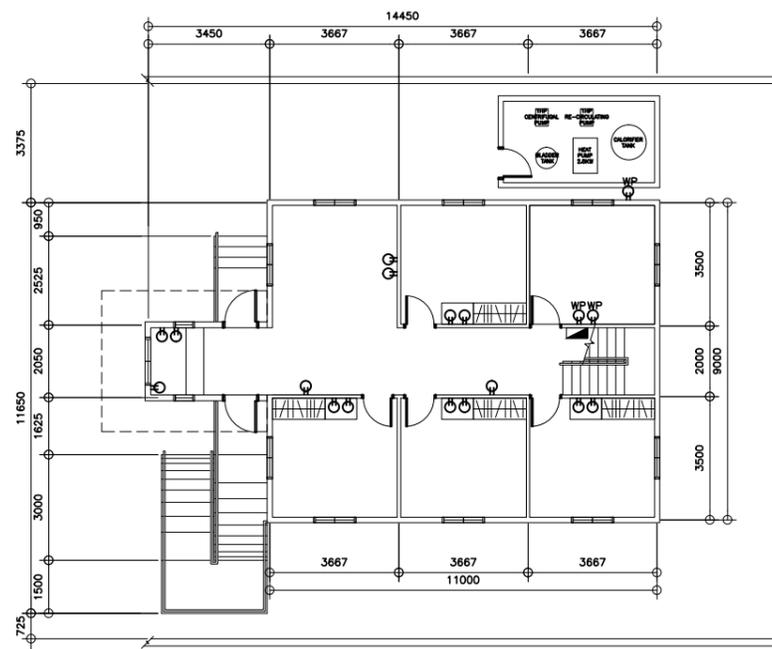


**1**  
E-2  
**GROUND FLOOR POWER LAYOUT**  
SCALE 1:200M

**2**  
E-2  
**SECOND FLOOR POWER LAYOUT**  
SCALE 1:200M

<p>REPUBLIC OF THE PHILIPPINES DEPARTMENT OF EDUCATION EDUCATION FACILITIES DIVISION MERALCO AVENUE, PASIG CITY</p>	DRAWN BY :  CAMILLE ANN C. RAPOSA CAD OPERATOR EFD-DepED	CHECKED BY :  JASON ALMOITE R2/CAR PMO MANAGER EFD-DepED	RECOMMENDING APPROVAL :  LUIS G. PURISIMA, JR. ASST. CHIEF, EFD-AS DepED	RECOMMENDING APPROVAL :  ANNABELLE R. HANGAN CHIEF OFFICE OF THE CHIEF, EFD-AS	APPROVED BY :  ALAIN DEL B. PASCUA UNDERSECRETARY FOR ADMINISTRATION	PROJECT TITLE : <b>REPAIR/REHABILITATION/RESTORATION OF BACHELORS HALL</b> LOCATION :	PROJECT CODE :	OWNER : <b>DEPARTMENT OF EDUCATION DepED</b> SHEET CONTENTS : - POWER LAYOUTS	SHEET NO : <b>E-2</b> <b>4</b>
---	--	--	--	--	--	---	----------------	--	--------------------------------------

LEGEND	
	BULLET/DOME TYPE CAMERA
	NETWORK VIDEO RECORDER

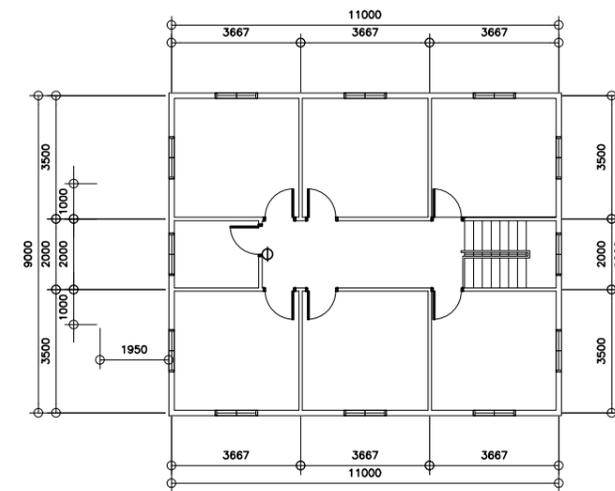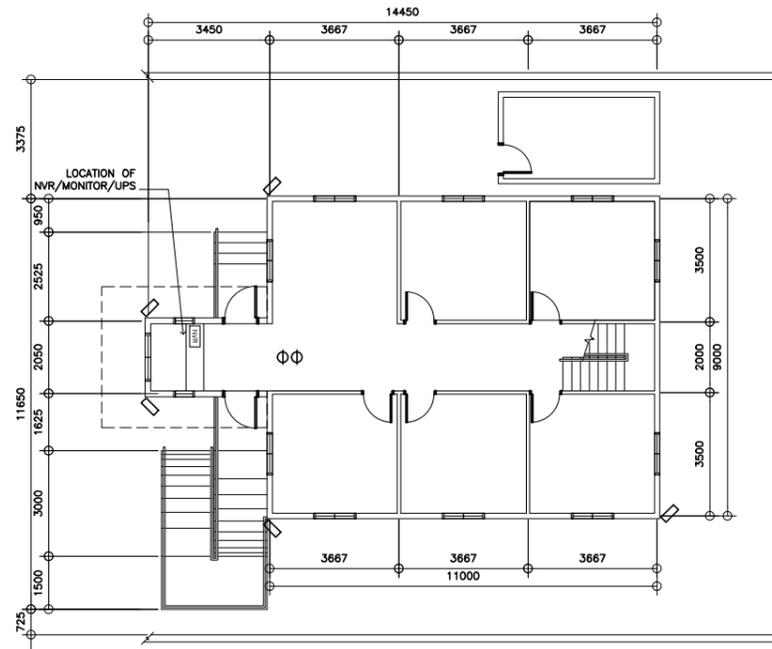



**1**  
E-3  
**GROUND FLOOR CCTV LAYOUT**  
SCALE 1:200M

**2**  
E-3  
**SECOND FLOOR CCTV LAYOUT**  
SCALE 1:200M

<p>REPUBLIC OF THE PHILIPPINES DEPARTMENT OF EDUCATION EDUCATION FACILITIES DIVISION MERALCO AVENUE, PASIG CITY</p>	DRAWN BY :  CAMILLE ANN C. RAPOSA CAD OPERATOR EFD-DepED	CHECKED BY :  JASON ALMOITE R2/CAR PMO MANAGER EFD-DepED	RECOMMENDING APPROVAL :  LUIS G. PURISIMA, JR. ASST. CHIEF, EFD-AS DepED	RECOMMENDING APPROVAL :  ANNABELLE R. HANGAN CHIEF OFFICE OF THE CHIEF, EFD-AS	APPROVED BY :  ALAIN VEL. B. PASCUA UNDERSECRETARY FOR ADMINISTRATION	PROJECT TITLE : <b>REPAIR/REHABILITATION/RESTORATION OF BACHELORS HALL</b> LOCATION :	PROJECT CODE :	OWNER : <b>DEPARTMENT OF EDUCATION DepED</b> SHEET CONTENTS : - CCTV LAYOUTS	SHEET NO : <b>E-3</b> <b>4</b>
---	--	--	--	--	---	---	----------------	---	--------------------------------------

LEGEND	
○SD	SMOKE DETECTOR
⊗SP	SPEAKER
⊞	EMERGENCY LIGHT
□MS	MANUAL STATION
○FB	FIRE ALARM BELL

AMP	AMPLIFIER
FACP	FIRE ALARM CONTROL PANEL
EXIT	EXIT SIGNAGE
⊞	2-BEAM EMERGENCY LIGHT

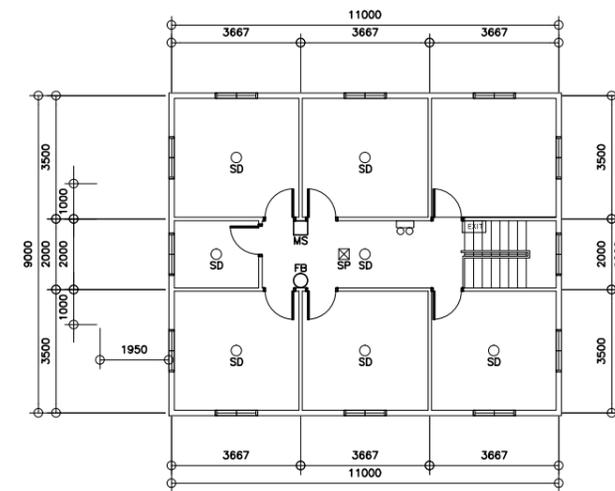
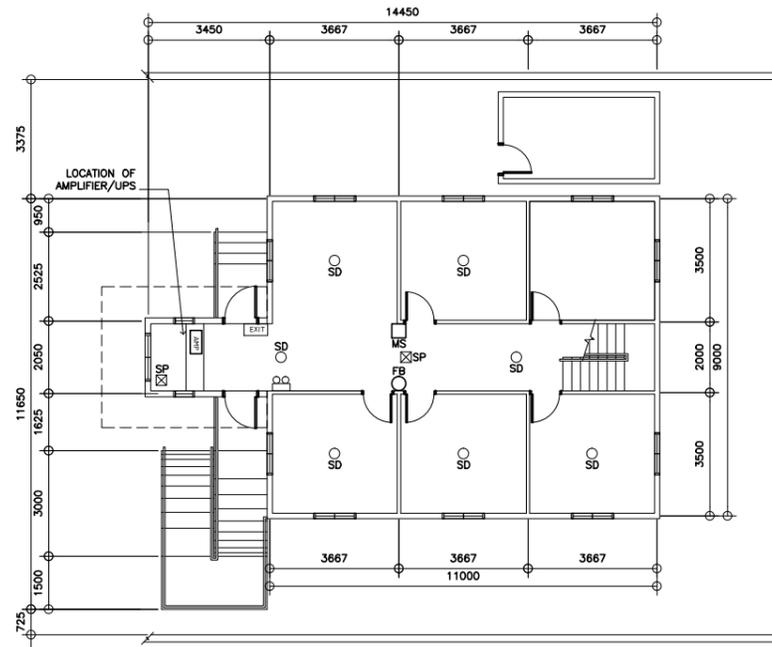


1  
E-4  
GROUND FLOOR AUDIO/FIRE LAYOUT  
SCALE 1:200M

2  
E-4  
SECOND FLOOR AUDIO/FIRE LAYOUT  
SCALE 1:200M

 REPUBLIC OF THE PHILIPPINES DEPARTMENT OF EDUCATION EDUCATION FACILITIES DIVISION MERALCO AVENUE, PASIG CITY	DRAWN BY :  <b>CAMILLE ANN C. RAPOSA</b> CAD OPERATOR EFD-DepED	CHECKED BY :  <b>JASON ALMOITE</b> R2/CAR PMO MANAGER EFD-DepED	RECOMMENDING APPROVAL :  <b>LUIS G. PURISIMA, JR.</b> ASST. CHIEF, EFD-AS DepED	RECOMMENDING APPROVAL :  <b>ANNABELLE R. HANGAN</b> CHIEF OFFICE OF THE CHIEF, EFD-AS	APPROVED BY :  <b>ALAIN VEL. B. PASCUA</b> UNDERSECRETARY FOR ADMINISTRATION	PROJECT TITLE : <b>REPAIR/REHABILITATION/RESTORATION  OF BACHELORS HALL</b>	PROJECT CODE :	OWNER : <b>DEPARTMENT OF EDUCATION  DepED</b>	SHEET NO : <b>E-4</b>
	SHEET CONTENTS : - AUDIO/FIRE LAYOUTS								<b>4</b>

LEGEND	
	6" RECESSED TYPE DOWNLIGHT
	8" TUBULAR TYPE HOUSING, WITH LED BULB
	4" TUBULAR TYPE HOUSING, WITH LED BULB
	4" RECESSED TYPE DOWNLIGHT
	CHANDELIER
	INDUSTRIAL TYPE, TB BULB
	POST LAMP

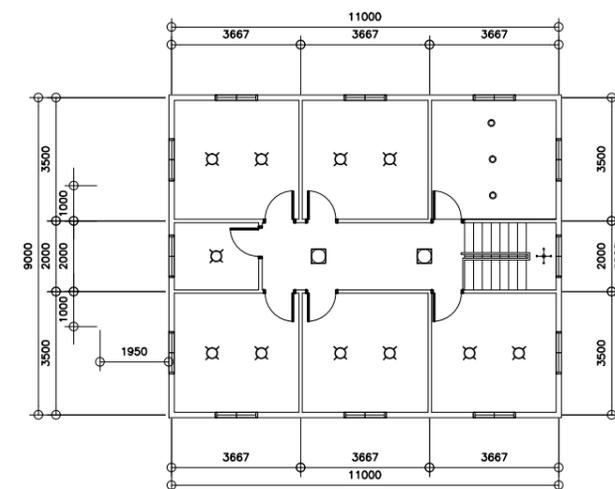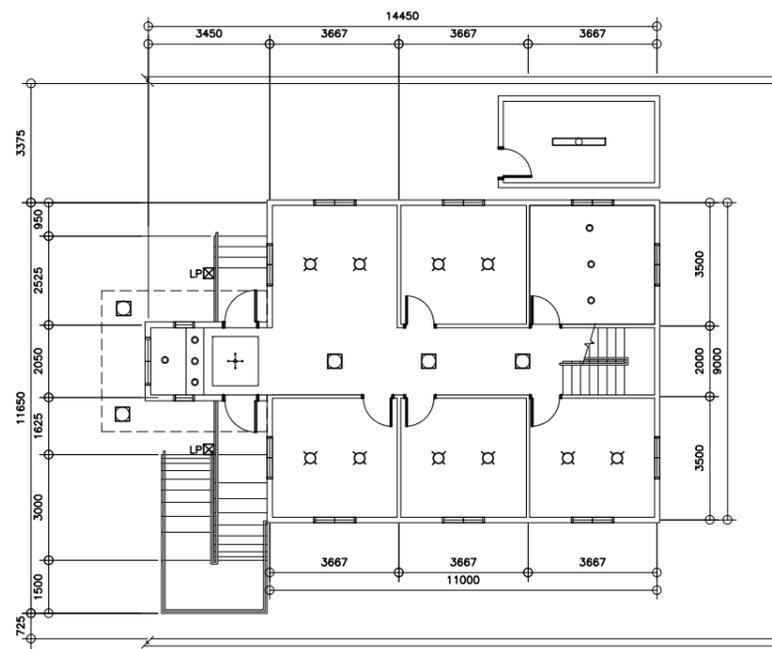

1  
E-1

## GROUND FLOOR LIGHTING LAYOUT

SCALE 1:200M

2  
E-1

## SECOND FLOOR LIGHTING LAYOUT

SCALE 1:200M

<p>REPUBLIC OF THE PHILIPPINES DEPARTMENT OF EDUCATION EDUCATION FACILITIES DIVISION MERALCO AVENUE, PASIG CITY</p>	DRAWN BY :  CAMILLE ANN C. RAPOSA CAD OPERATOR EFD-DepED	CHECKED BY :  JASON ALMOITE R2/CAR PMO MANAGER EFD-DepED	RECOMMENDING APPROVAL :  LUIS G. PURISIMA, JR. ASST. CHIEF, EFD-AS DepED	RECOMMENDING APPROVAL :  ANNABELLE R. HANGAN CHIEF OFFICE OF THE CHIEF, EFD-AS	APPROVED BY :  ALAIN VEL B. PASCUA UNDERSECRETARY FOR ADMINISTRATION	PROJECT TITLE : <b>REPAIR/REHABILITATION/RESTORATION OF BACHELORS HALL</b>	PROJECT CODE :	OWNER : DEPARTMENT OF EDUCATION DepED	SHEET NO : E-1 4
	LOCATION :						SHEET CONTENTS : - LIGHTING LAYOUTS		