


1
A-1

GROUND FLOOR PLAN

SCALE 1:200M

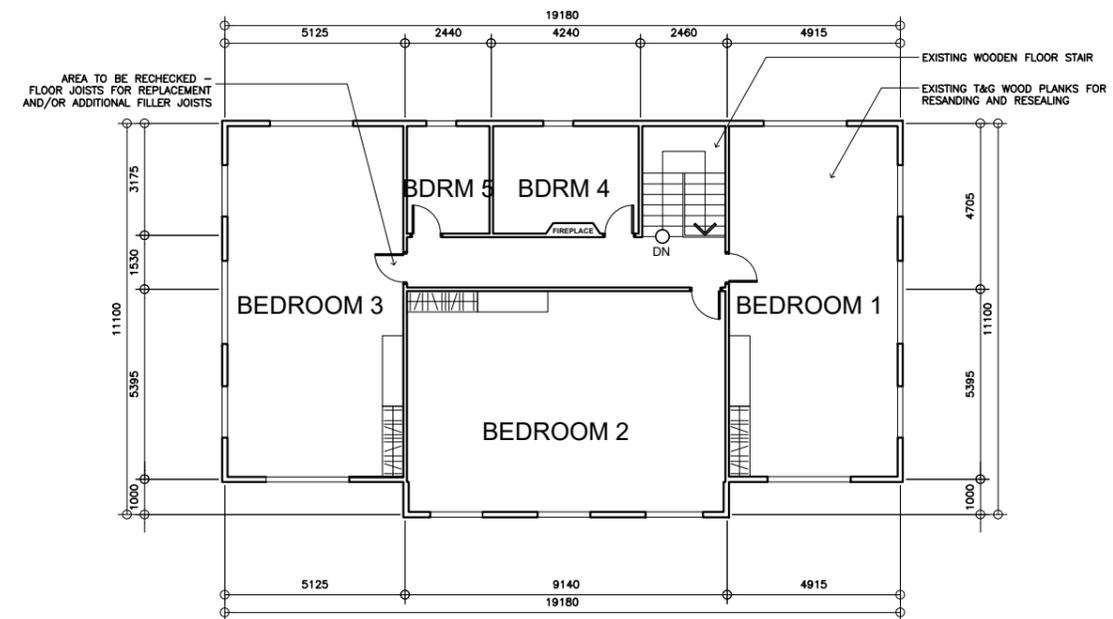


2
A-1


SECOND FLOOR PLAN

SCALE 1:200M


<p>REPUBLIC OF THE PHILIPPINES DEPARTMENT OF EDUCATION EDUCATION FACILITIES DIVISION MERALCO AVENUE, PASIG CITY</p>	<p>DRAWN BY :</p> <p><i>Camille Raposa</i> CAMILLE RAPOSA/REICHELLE PORMILDA CAD OPERATOR EFD-DepED</p>	<p>CHECKED BY :</p> <p><i>Jason Almoite</i> JASON ALMOITE R2/CAR PMO MANAGER EFD-DepED</p>	<p>RECOMMENDING APPROVAL :</p> <p><i>Luis G. Purisima, Jr.</i> LUIS G. PURISIMA, JR. ASST. CHIEF, EFD-AS DepED</p>	<p>RECOMMENDING APPROVAL :</p> <p><i>Annabelle R. Hangan</i> ANNABELLE R. HANGAN CHIEF OFFICE OF THE CHIEF, EFD-AS</p>	<p>APPROVED BY :</p> <p><i>Alain Vel. B. Pascua</i> ALAIN VEL. B. PASCUA UNDERSECRETARY FOR ADMINISTRATION</p>	<p>PROJECT TITLE :</p> <p>REPAIR/REHABILITATION/RESTORATION OF ESCODA HALL</p>	<p>PROJECT CODE :</p>	<p>OWNER :</p> <p>DEPARTMENT OF EDUCATION DepED</p>	<p>SHEET NO.:</p> <p>A-1 3</p>
	<p>SHEET CONTENTS : FLOOR PLANS</p>						<p>LOCATION :</p>		

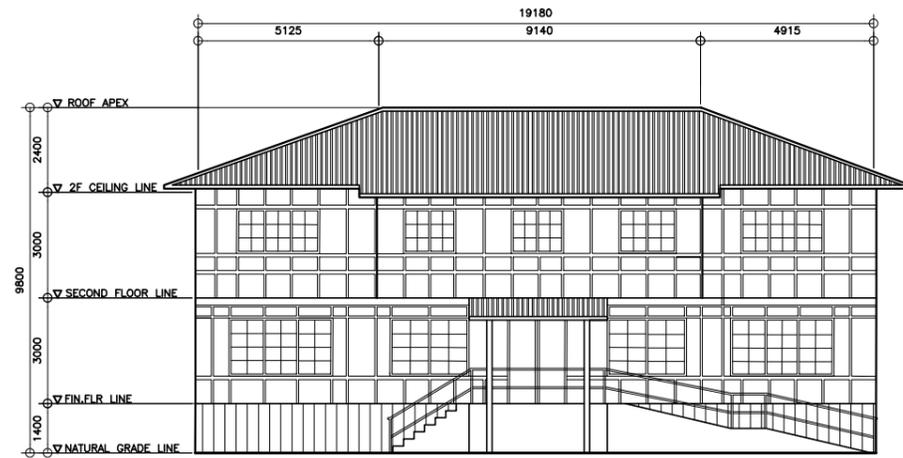


1 FRONT ELEVATION
A-2 SCALE 1:200M

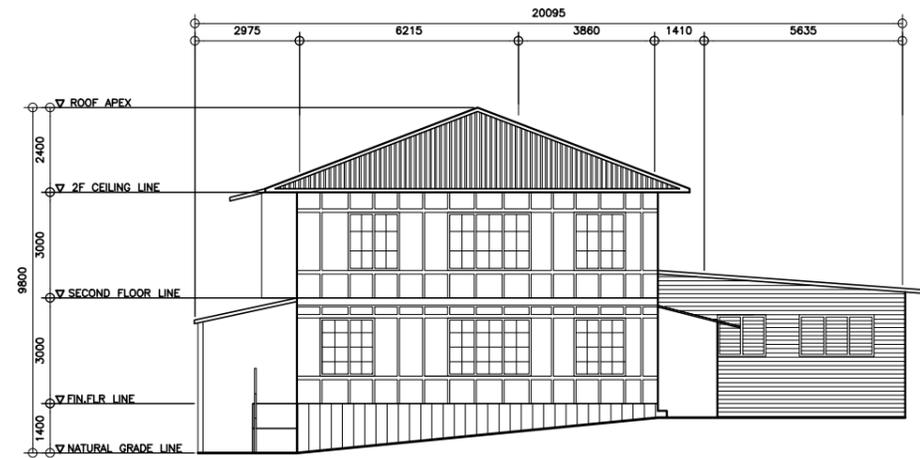

2 RIGHT SIDE ELEVATION
A-2 SCALE 1:200M

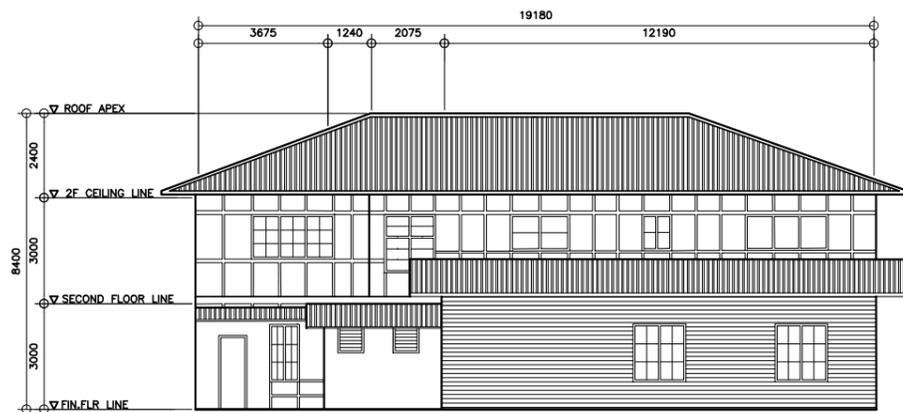


3 REAR ELEVATION
A-2 SCALE 1:200M

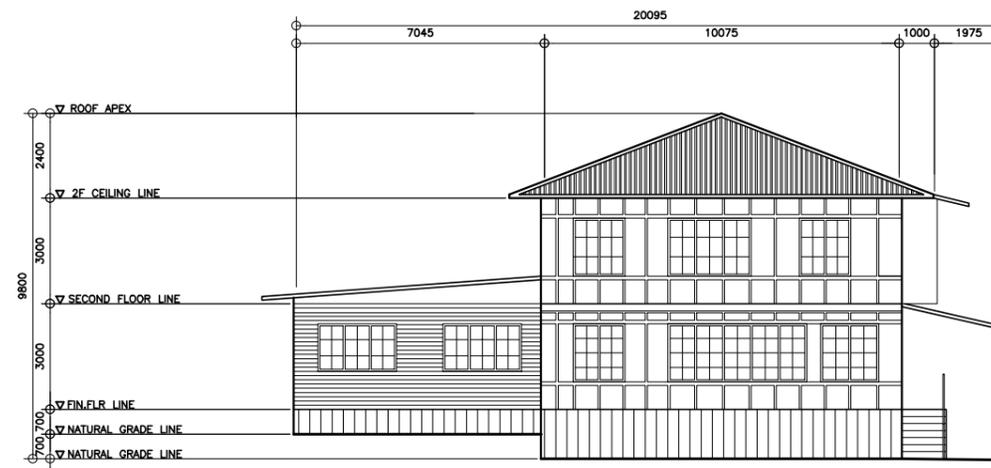


4 LEFT SIDE ELEVATION
A-2 SCALE 1:200M

 <p>REPUBLIC OF THE PHILIPPINES DEPARTMENT OF EDUCATION EDUCATION FACILITIES DIVISION MERALCO AVENUE, PASIG CITY</p>	DRAWN BY :  CAMILLE ANN C. RAPOSA CAD OPERATOR EFD-DepED	CHECKED BY :  JASON ALMOITE R2/CAR PMO MANAGER EFD-DepED	RECOMMENDING APPROVAL :  LUIS G. PURISIMA, JR. ASST. CHIEF, EFD-AS DepED	RECOMMENDING APPROVAL :  ANNABELLE R. HANGAN CHIEF OFFICE OF THE CHIEF, EFD-AS	APPROVED BY :  ALAIN VEL B. PASCUA UNDERSECRETARY FOR ADMINISTRATION	PROJECT TITLE : REPAIR/REHABILITATION/RESTORATION OF ESCODA HALL LOCATION :	PROJECT CODE :	OWNER : DEPARTMENT OF EDUCATION DepED SHEET CONTENTS : - ELEVATIONS	SHEET NO : A-2 3
---	---	---	---	---	---	--	----------------	---	------------------------

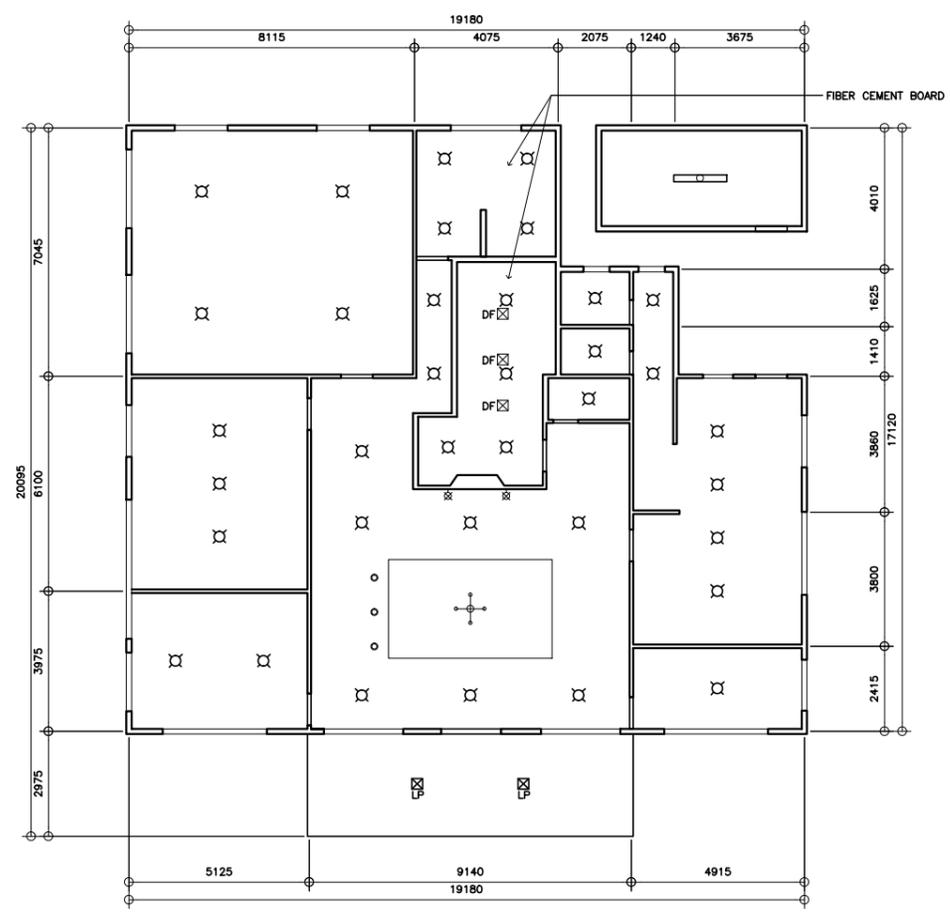

LEGEND	
☒	-
○	-
+	CHANDELIER
☒LP	LAMP POST
☒DF	-

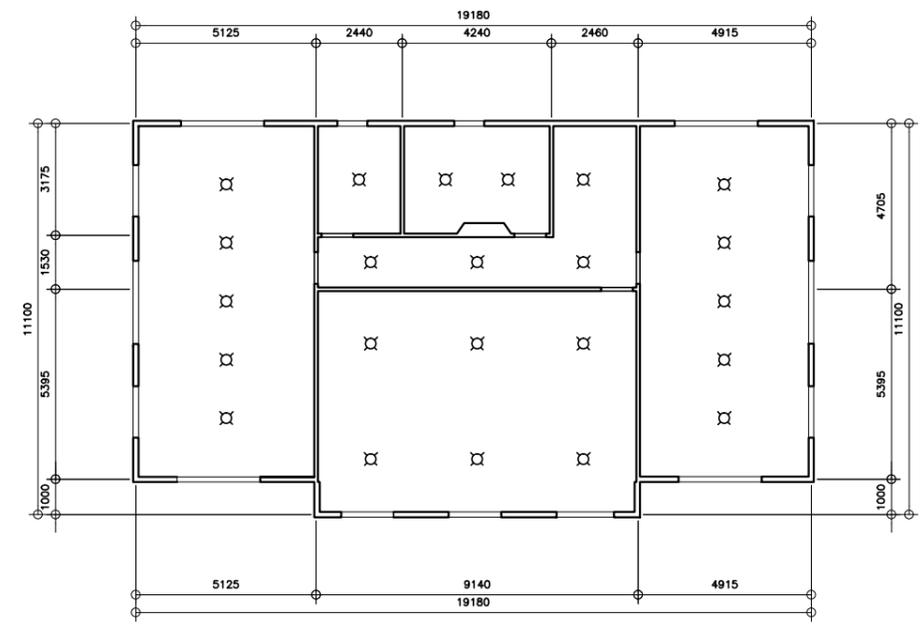


1
A-3

GROUND FLOOR REFLECTED CEILING PLAN
SCALE 1:100M


2
A-3

SECOND FLOOR REFLECTED CEILING PLAN
SCALE 1:100M

<p>REPUBLIC OF THE PHILIPPINES DepED DEPARTMENT OF EDUCATION EDUCATION FACILITIES DIVISION MERALCO AVENUE, PASIG CITY</p>	DRAWN BY : CAMILLE ANN C. RAPOSA CAD OPERATOR EFD-DepED	CHECKED BY : JASON ALMOITE R2/CAR PMO MANAGER EFD-DepED	RECOMMENDING APPROVAL : LUIS G. PURISIMA, JR. ASST. CHIEF, EFD-AS DepED	RECOMMENDING APPROVAL : ANNABELLE R. PANGAN CHIEF OFFICE OF THE CHIEF, EFD-AS	APPROVED BY : ALAIN VEL. B. PASCUA UNDERSECRETARY FOR ADMINISTRATION	PROJECT TITLE : REPAIR/REHABILITATION/RESTORATION OF ESCODA HALL LOCATION :	PROJECT CODE :	OWNER : DEPARTMENT OF EDUCATION DepED	SHEET NO.: A-3 SHEET CONTENTS : REFLECTED CEILING PLANS 3
	SHEET CONTENTS : REFLECTED CEILING PLANS								

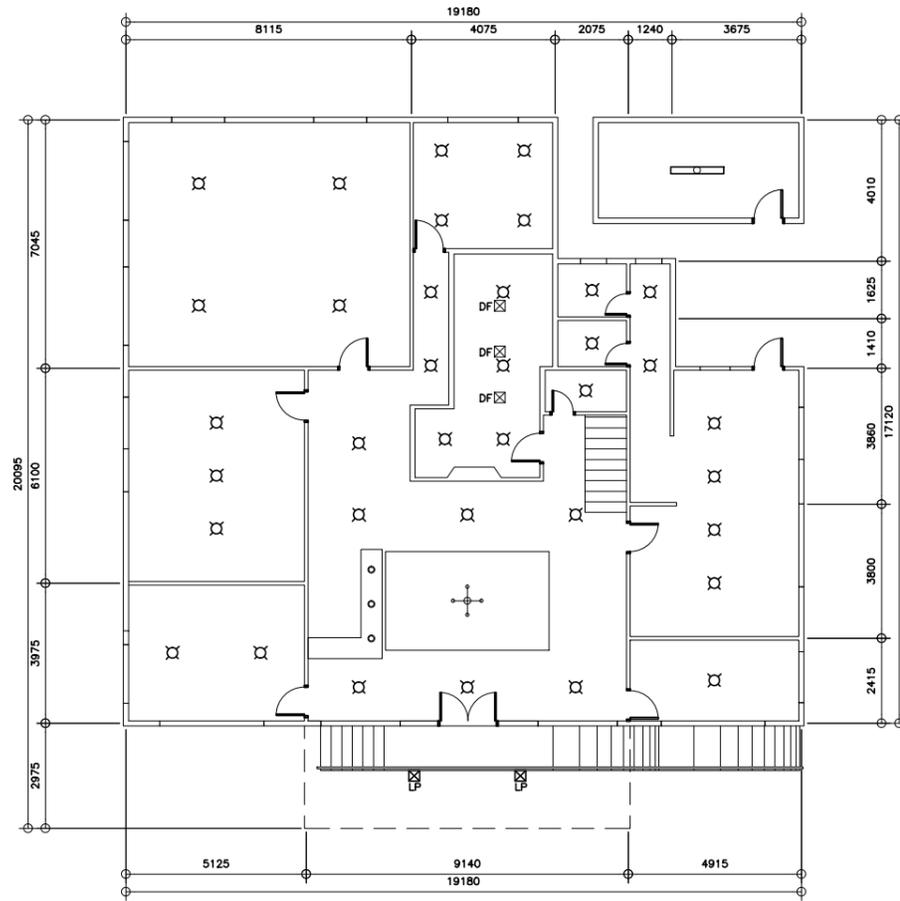

LEGEND	
⊗	-
○	-
+	CHANDELIER
□	-
⊗LP	LAMP POST
⊗DF	-

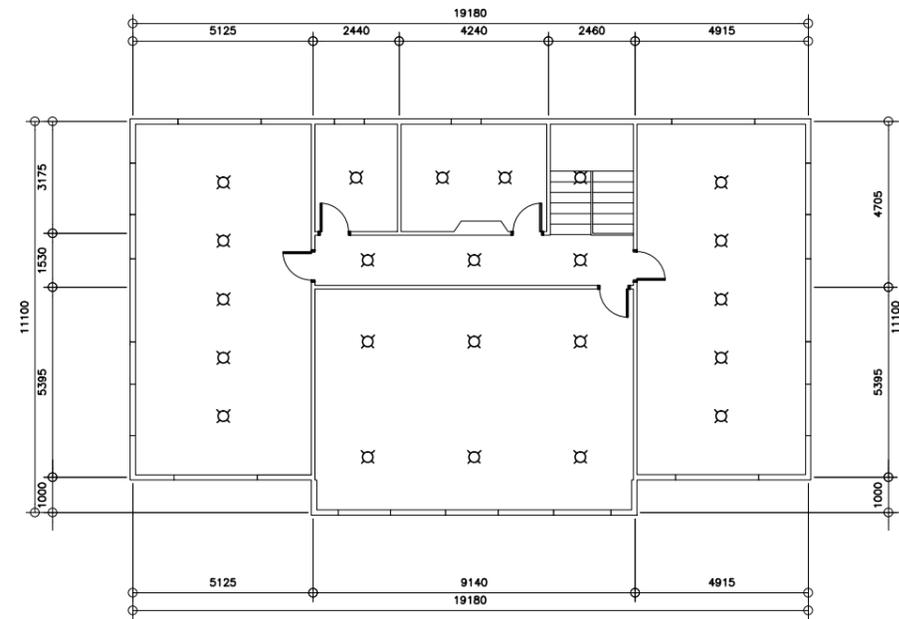

1
E-1

GROUND FLOOR LIGHTING LAYOUT

SCALE 1:100M



2
E-1

SECOND FLOOR LIGHTING LAYOUT

SCALE 1:100M

<p>REPUBLIC OF THE PHILIPPINES DEPARTMENT OF EDUCATION EDUCATION FACILITIES DIVISION MERALCO AVENUE, PASIG CITY</p>	DRAWN BY : CAMILLE ANN C. RAPOSA CAD OPERATOR EFD-DepED	CHECKED BY : JASON ALMOITE R2/CAR PMO MANAGER EFD-DepED	RECOMMENDING APPROVAL : LUIS G. PURISIMA, JR. ASST. CHIEF, EFD-AS DepED	RECOMMENDING APPROVAL : ANNABELLE R. PANGAN CHIEF OFFICE OF THE CHIEF, EFD-AS	APPROVED BY : ALAIN VEL. B. PASCUA UNDERSECRETARY FOR ADMINISTRATION	PROJECT TITLE : REPAIR/REHABILITATION/RESTORATION OF ESCODA HALL	PROJECT CODE :	OWNER : DEPARTMENT OF EDUCATION DepED	SHEET NO.: E-1 4
	SHEET CONTENTS : - LIGHTING LAYOUTS						LOCATION :		

LEGEND	
	DUPLEX CONVENIENCE OUTLET
	WEATHERPROOF DUPLEX CONVENIENCE OUTLET
	PANELBOARD

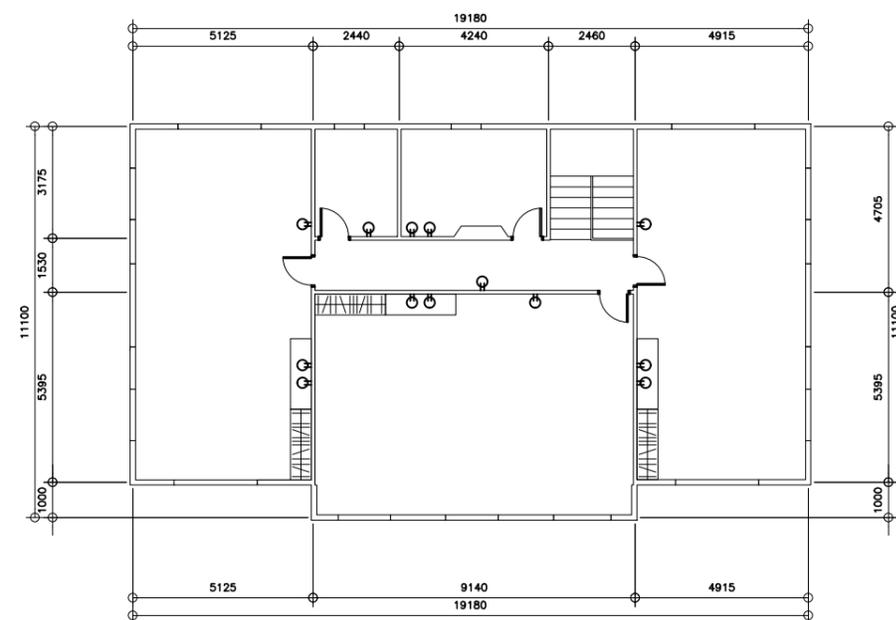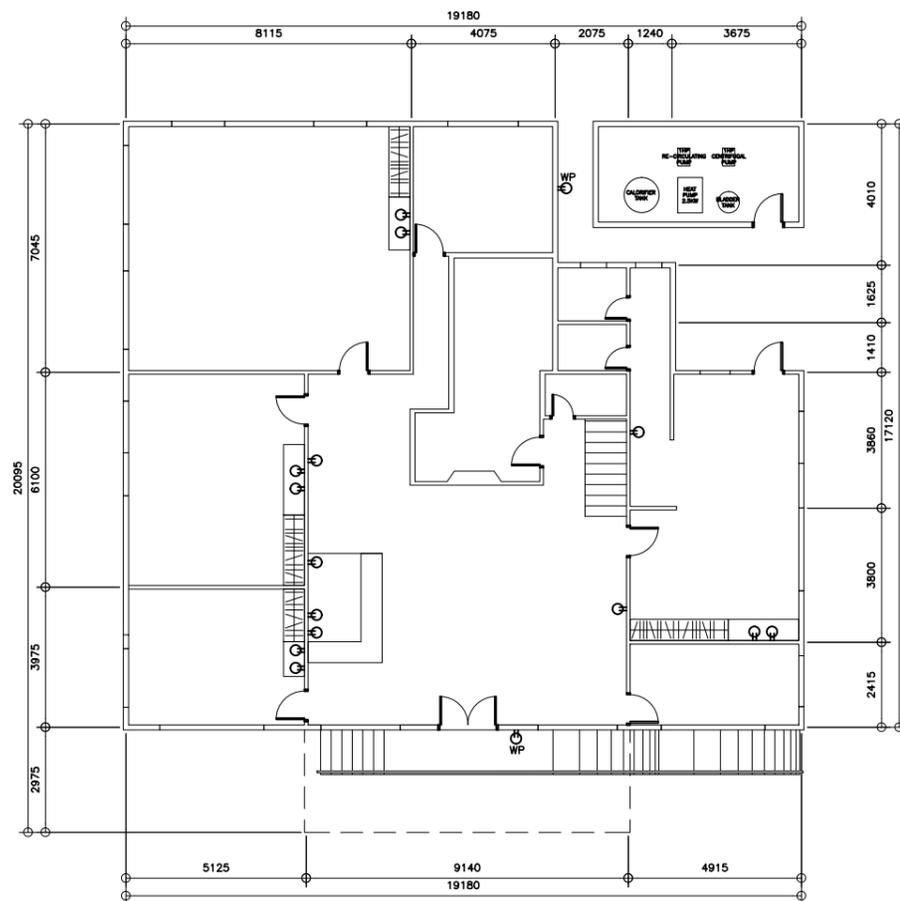


1
E-1
GROUND FLOOR POWER LAYOUT
SCALE 1:100M


2
E-1
SECOND FLOOR POWER LAYOUT
SCALE 1:100M

REPUBLIC OF THE PHILIPPINES DEPARTMENT OF EDUCATION EDUCATION FACILITIES DIVISION MERALCO AVENUE, PASIG CITY	DRAWN BY : CAMILLE ANN C. RAPOSA CAD OPERATOR EFD-DepED	CHECKED BY : JASON ALMOITE R2/CAR PMO MANAGER EFD-DepED	RECOMMENDING APPROVAL : LUIS G. PURISIMA, JR. ASST. CHIEF, EFD-AS DepED	RECOMMENDING APPROVAL : ANNABELLE R. PANGAN CHIEF OFFICE OF THE CHIEF, EFD-AS	APPROVED BY : ALAIN VEL. B. PASCUA UNDERSECRETARY FOR ADMINISTRATION	PROJECT TITLE : REPAIR/REHABILITATION/RESTORATION OF ESCODA HALL LOCATION :	PROJECT CODE :	OWNER : DEPARTMENT OF EDUCATION DepED SHEET CONTENTS : - POWER LAYOUTS	SHEET NO : E-2 4
---	--	--	--	--	---	--	----------------	--	--------------------------------------

LEGEND	
⊕	-
□	-

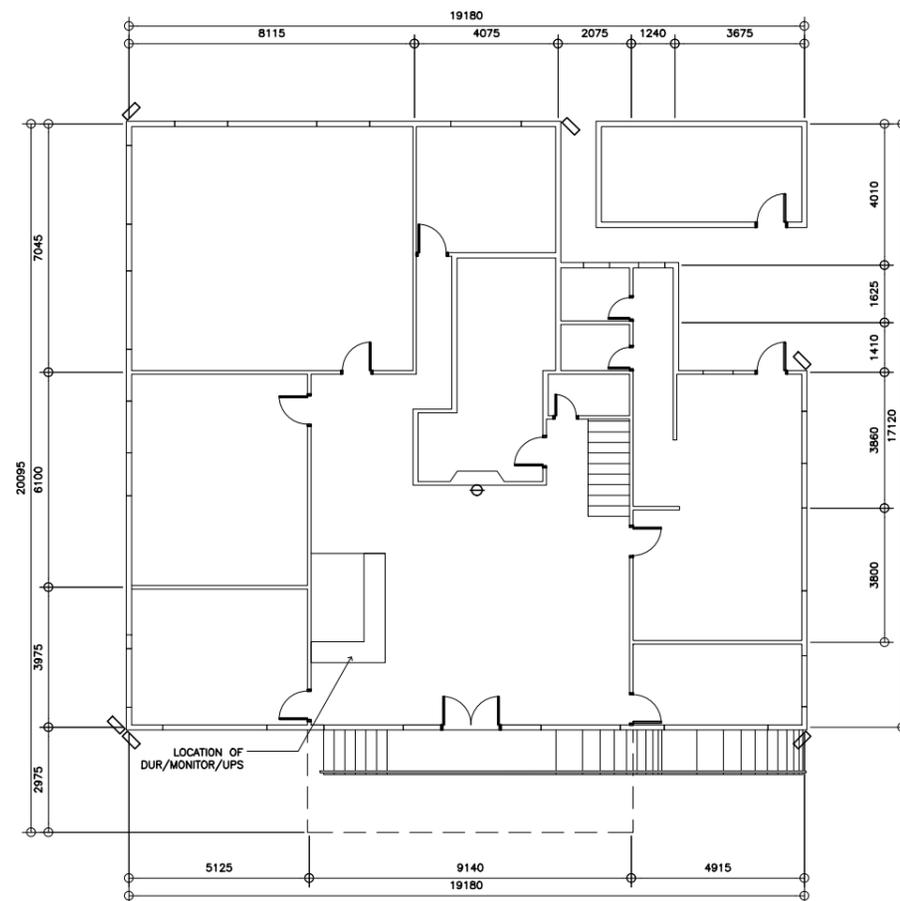



1
E-3
GROUND FLOOR CCTV LAYOUT
SCALE 1:100M

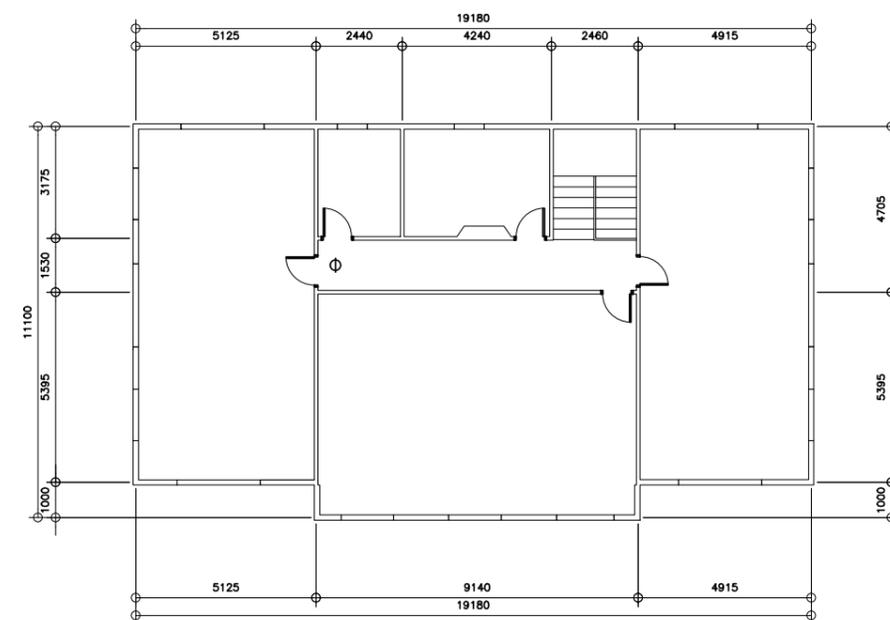

2
E-3
SECOND FLOOR CCTV LAYOUT
SCALE 1:100M

<p>REPUBLIC OF THE PHILIPPINES DEPARTMENT OF EDUCATION EDUCATION FACILITIES DIVISION MERALCO AVENUE, PASIG CITY</p>	DRAWN BY : CAMILLE ANN C. RAPOSA CAD OPERATOR EFD-DepED	CHECKED BY : JASON ALMOITE R2/CAR PMO MANAGER EFD-DepED	RECOMMENDING APPROVAL : LUIS G. PURISIMA, JR. ASST. CHIEF, EFD-AS DepED	RECOMMENDING APPROVAL : ANNABELLE R. PANGAN CHIEF OFFICE OF THE CHIEF, EFD-AS	APPROVED BY : ALAIN VEL. B. PASCUA UNDERSECRETARY FOR ADMINISTRATION	PROJECT TITLE : REPAIR/REHABILITATION/RESTORATION OF ESCODA HALL LOCATION :	PROJECT CODE :	OWNER : DEPARTMENT OF EDUCATION DepED SHEET CONTENTS : -- CCTV LAYOUTS	SHEET NO : <div style="border: 1px solid black; border-radius: 50%; width: 40px; height: 40px; display: flex; align-items: center; justify-content: center;"> <div style="border: 1px solid black; border-radius: 50%; width: 20px; height: 20px; display: flex; align-items: center; justify-content: center;"> E-3 </div> <div style="margin-left: 5px;">4</div> </div>
---	--	--	--	--	---	--	----------------	---	--

LEGEND	
○SD	SMOKE DETECTOR
⊠SP	SPEAKER
⊠EL	EMERGENCY LIGHT
⊠MS	-
○FB	-
⊠FACP	-

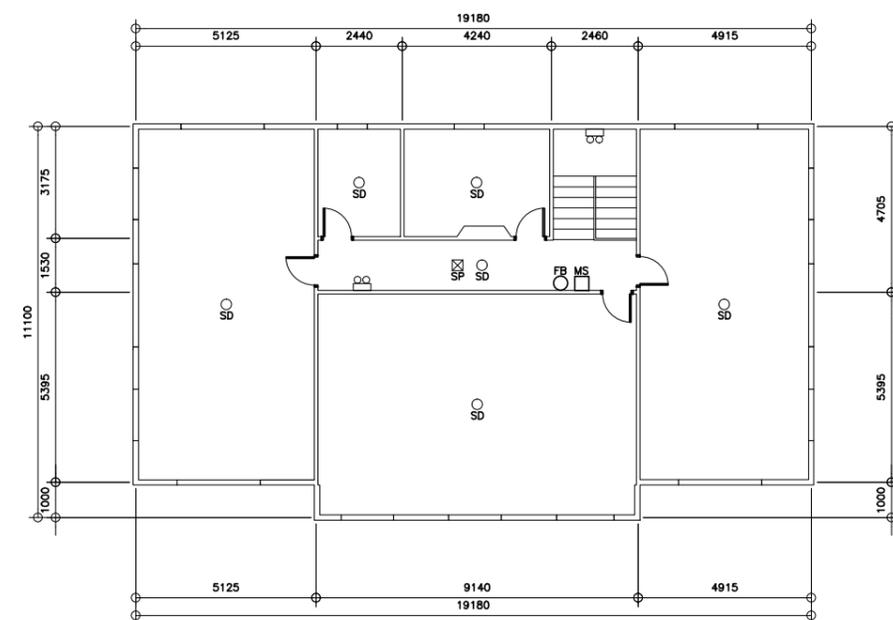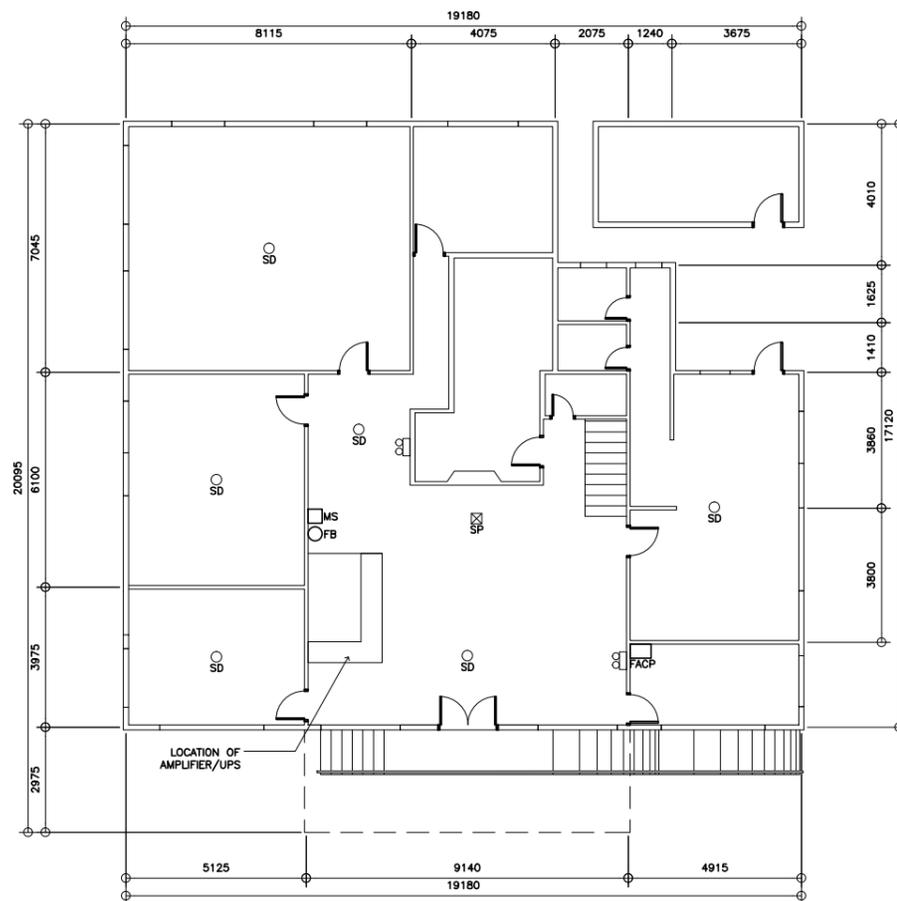

1
E-4
GROUND FLOOR AUDIO/FIRE LAYOUT
SCALE 1:100M

2
E-4
SECOND FLOOR AUDIO/FIRE LAYOUT
SCALE 1:100M

 REPUBLIC OF THE PHILIPPINES DEPARTMENT OF EDUCATION EDUCATION FACILITIES DIVISION MERALCO AVENUE, PASIG CITY	DRAWN BY : CAMILLE ANN C. RAPOSA CAD OPERATOR EFD-DepED	CHECKED BY : JASON ALMOITE R2/CAR PMO MANAGER EFD-DepED	RECOMMENDING APPROVAL : LUIS G. PURISIMA, JR. ASST. CHIEF, EFD-AS DepED	RECOMMENDING APPROVAL : ANNABELLE R. PANGAN CHIEF OFFICE OF THE CHIEF, EFD-AS	APPROVED BY : ALAIN VEL. B. PASCUA UNDERSECRETARY FOR ADMINISTRATION	PROJECT TITLE : REPAIR/REHABILITATION/RESTORATION OF ESCODA HALL LOCATION :	PROJECT CODE :	OWNER : DEPARTMENT OF EDUCATION DepED SHEET CONTENTS : - AUDIO/FIRE LAYOUTS	SHEET NO : E-4 4
---	--	--	--	--	---	--	----------------	---	------------------------