



1
GROUND FLOOR PLAN
A-1
SCALE
1:200M

REPUBLIC OF THE PHILIPPINES DEPARTMENT OF EDUCATION EDUCATION FACILITIES DIVISION MERALCO AVENUE, PASIG CITY	DRAWN BY : CAMILLE ANN C. RAPOSA CAD OPERATOR EFD-DepED	CHECKED BY : JASON ALMOITE R2/CAR PMO MANAGER EFD-DepED	RECOMMENDING APPROVAL : LUIS G. PURISIMA, JR. ASST. CHIEF, EFD-AS DepED	RECOMMENDING APPROVAL : ANNABELLE R. RANGAN CHIEF OFFICE OF THE CHIEF, EFD-AS	APPROVED BY : ALAIN VEL. B. PASCUA UNDERSECRETARY FOR ADMINISTRATION	PROJECT TITLE : REPAIR/REHABILITATION/RESTORATION OF RECTO HALL LOCATION :	PROJECT CODE :	OWNER : DEPARTMENT OF EDUCATION DepED SHEET CONTENTS : - GROUND FLOOR PLAN	SHEET NO : A-1 9
---	--	--	--	--	---	--	----------------	---	--

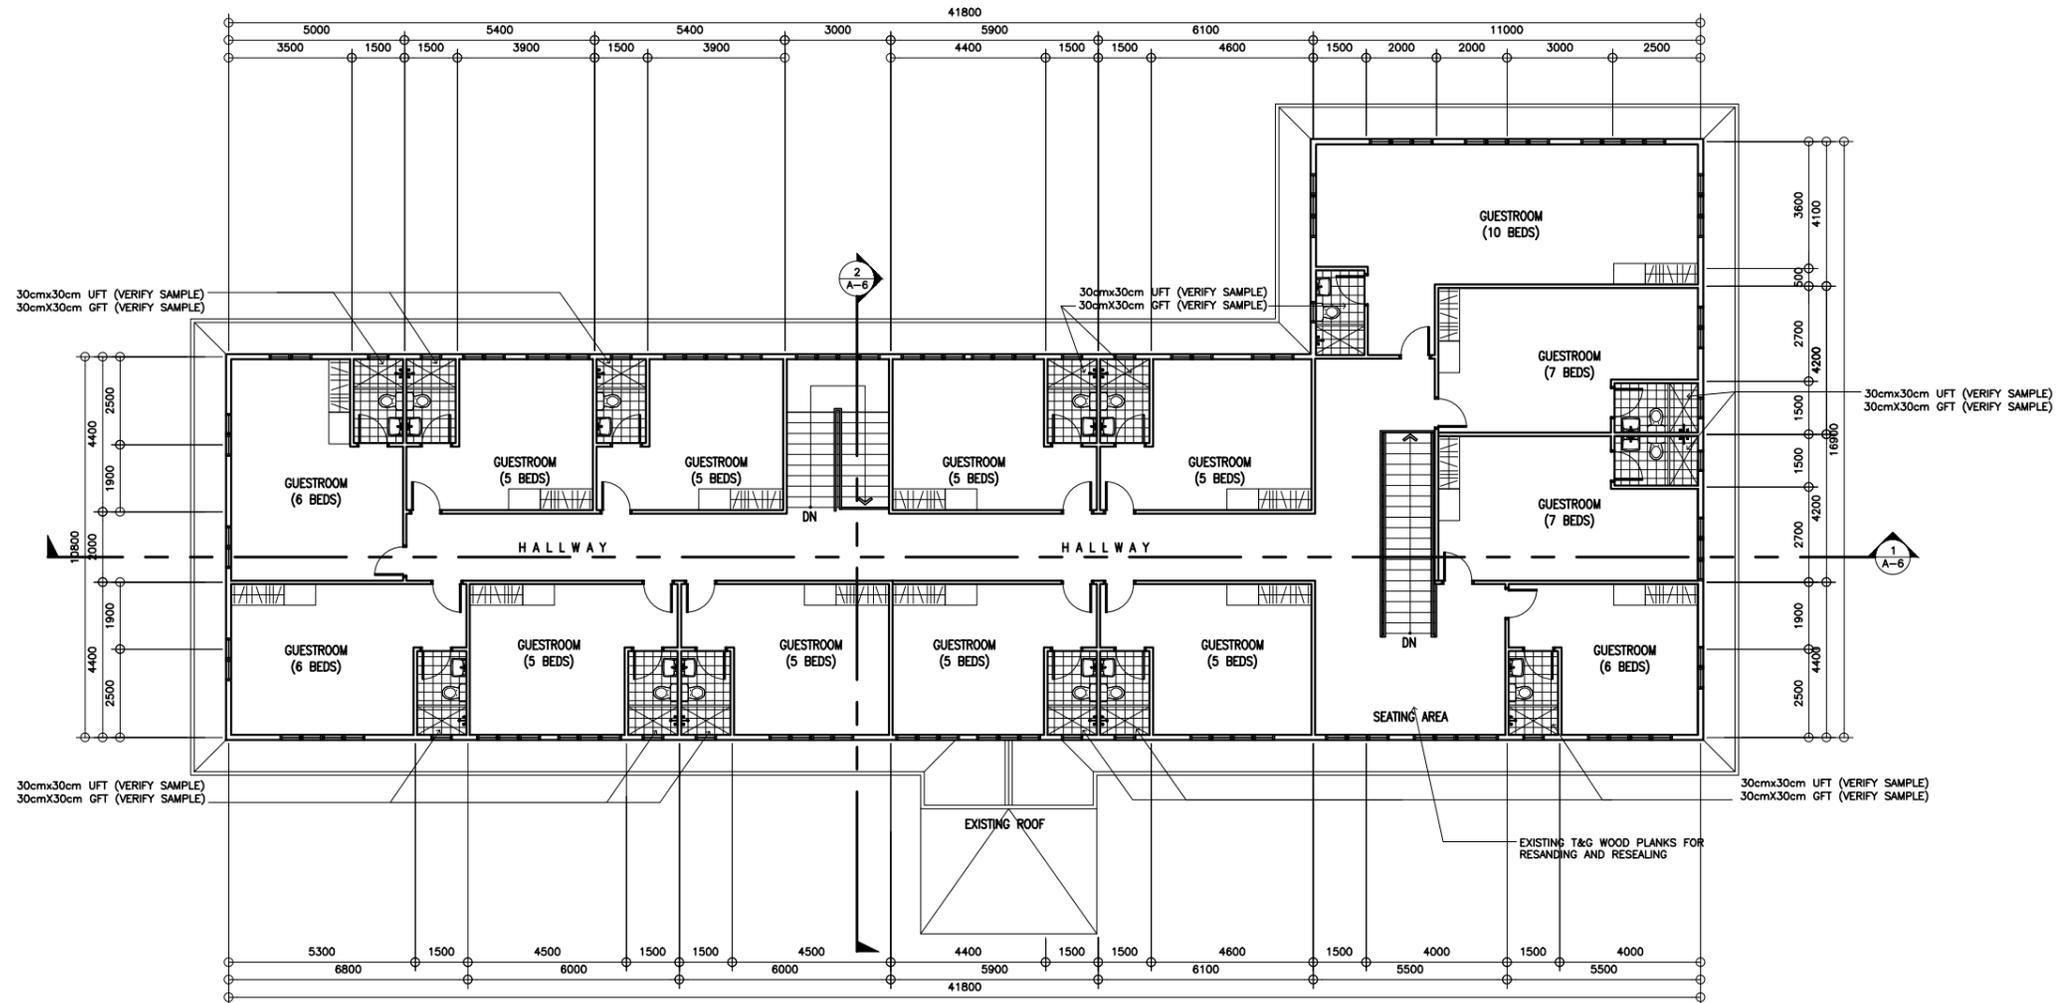


1
A-2
SECOND FLOOR PLAN
 SCALE 1:200M

REPUBLIC OF THE PHILIPPINES DEPARTMENT OF EDUCATION EDUCATION FACILITIES DIVISION MERALCO AVENUE, PASIG CITY	DRAWN BY : CAMILLE ANN C. RAPOSA CAD OPERATOR EFD-DepED	CHECKED BY : JASON ALMOITE R2/CAR PMO MANAGER EFD-DepED	RECOMMENDING APPROVAL : LUIS G. PURISIMA, JR. ASST. CHIEF, EFD-AS DepED	RECOMMENDING APPROVAL : ANNABELLE R. PANGAN CHIEF OFFICE OF THE CHIEF, EFD-AS	APPROVED BY : ALAIN VEL. B. PASCUA UNDERSECRETARY FOR ADMINISTRATION	PROJECT TITLE : REPAIR/REHABILITATION/RESTORATION OF RECTO HALL LOCATION :	PROJECT CODE :	OWNER : DEPARTMENT OF EDUCATION DepED SHEET CONTENTS : - SECOND FLOOR PLAN	SHEET NO: A-2 9
---	--	--	--	--	---	--	----------------	---	--

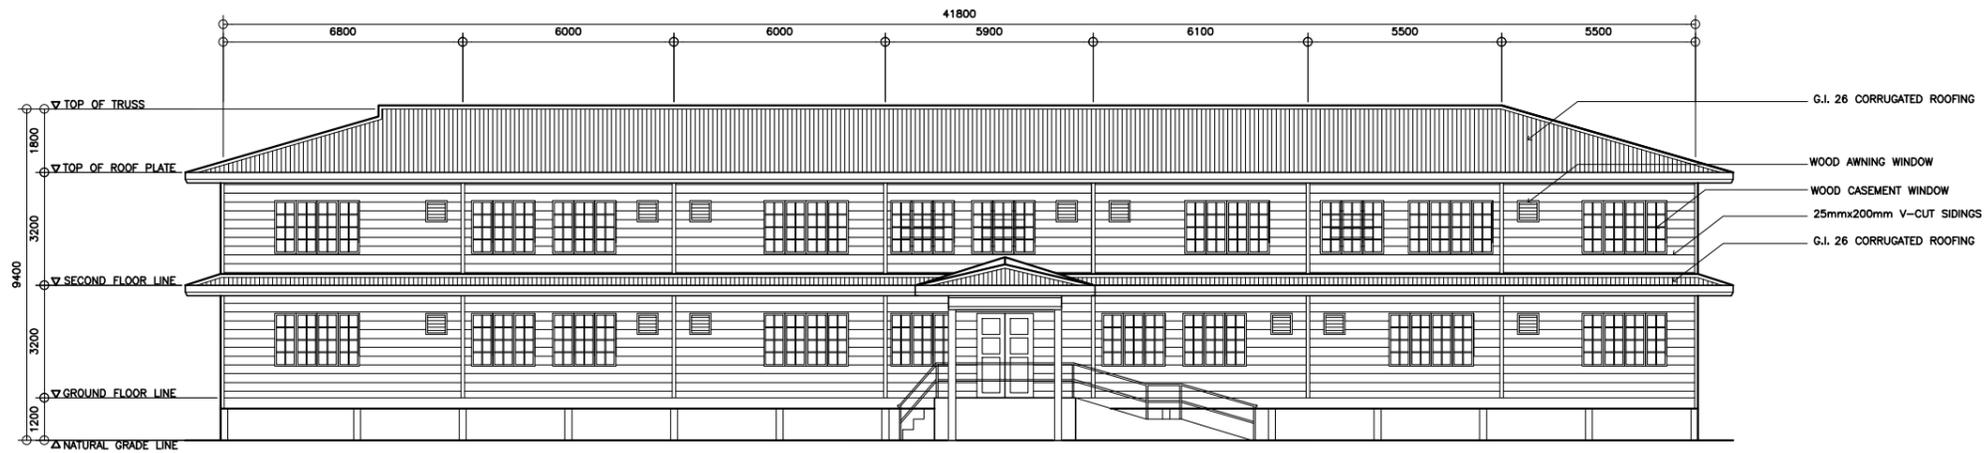



1
A-3
FRONT ELEVATION
 SCALE 1:200M

REPUBLIC OF THE PHILIPPINES DEPARTMENT OF EDUCATION EDUCATION FACILITIES DIVISION MERALCO AVENUE, PASIG CITY	DRAWN BY : CAMILLE ANN C. RAPOSA CAD OPERATOR EFD-DepED	CHECKED BY : JASON ALMOITE R2/CAR PMO MANAGER EFD-DepED	RECOMMENDING APPROVAL : LUIS G. PURISIMA, JR. ASST. CHIEF, EFD-AS DepED	RECOMMENDING APPROVAL : ANNABELLE R. HANGAN CHIEF OFFICE OF THE CHIEF, EFD-AS	APPROVED BY : ALAIN VEL. B. PASCUA UNDERSECRETARY FOR ADMINISTRATION	PROJECT TITLE : REPAIR/REHABILITATION/RESTORATION OF RECTO HALL LOCATION :	PROJECT CODE :	OWNER : DEPARTMENT OF EDUCATION DepED SHEET CONTENTS : - FRONT ELEVATION	SHEET NO : A-3 9
---	--	--	--	--	---	--	----------------	---	---

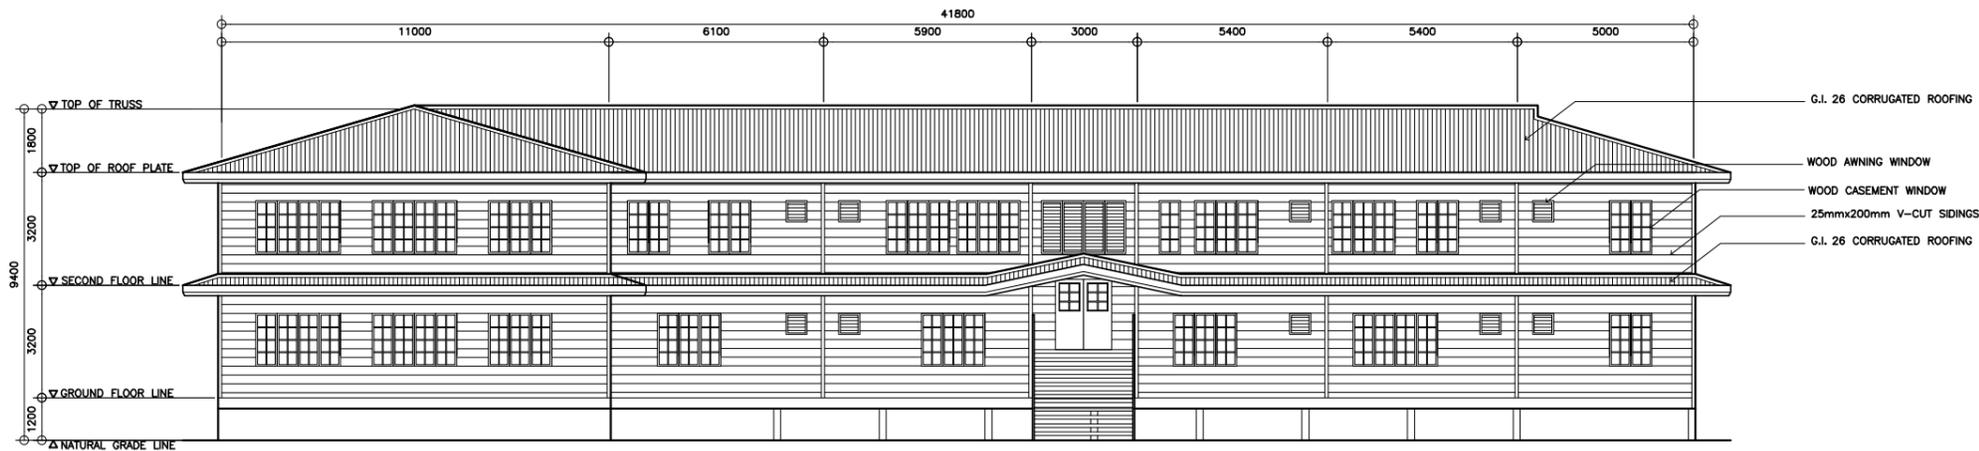

1
REAR ELEVATION
A-4
SCALE
1:200M


REPUBLIC OF THE PHILIPPINES DEPARTMENT OF EDUCATION EDUCATION FACILITIES DIVISION MERALCO AVENUE, PASIG CITY	DRAWN BY : CAMILLE ANN C. RAPOSA CAD OPERATOR EFD-DepED	CHECKED BY : JASON ALMOITE R2/CAR PMO MANAGER EFD-DepED	RECOMMENDING APPROVAL : LUIS G. PURISIMA, JR. ASST. CHIEF, EFD-AS DepED	RECOMMENDING APPROVAL : ANNABELLE R. PANGAN CHIEF OFFICE OF THE CHIEF, EFD-AS	APPROVED BY : ALAIN VEL. B. PASCUA UNDERSECRETARY FOR ADMINISTRATION	PROJECT TITLE : REPAIR/REHABILITATION/RESTORATION OF RECTO HALL LOCATION :	PROJECT CODE :	OWNER : DEPARTMENT OF EDUCATION DepED SHEET CONTENTS : - REAR ELEVATION	SHEET NO: A-4 9
---	--	--	--	--	---	--	----------------	--	---

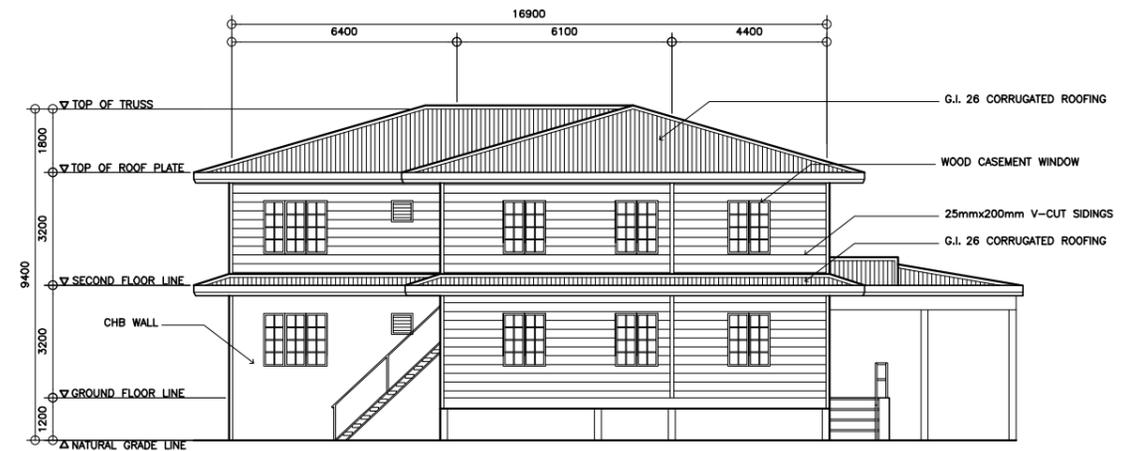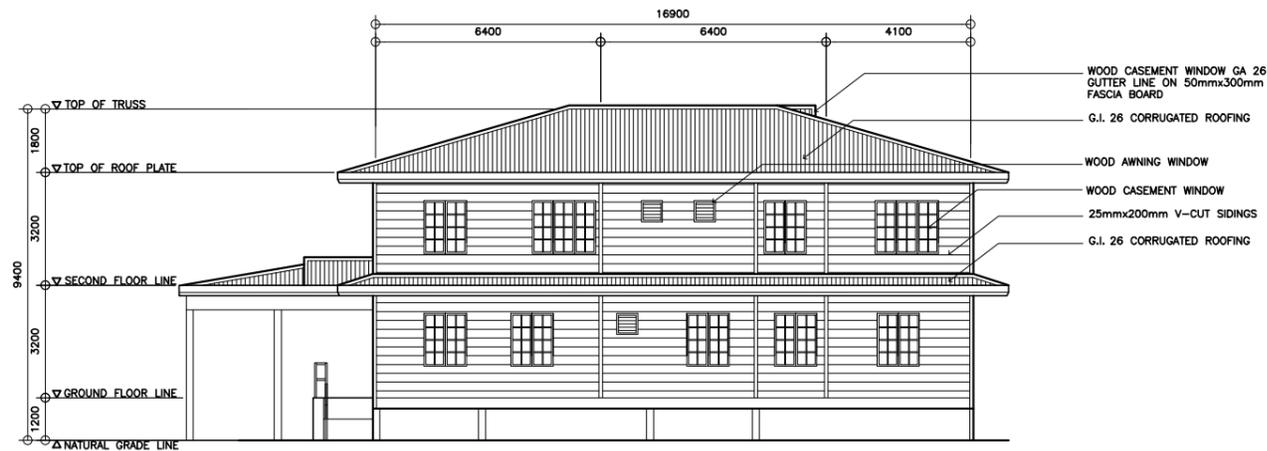


1 RIGHT SIDE ELEVATION
A-5 SCALE 1:200M

2 LEFT SIDE ELEVATION
A-5 SCALE 1:200M


<p>REPUBLIC OF THE PHILIPPINES DEPARTMENT OF EDUCATION EDUCATION FACILITIES DIVISION MERALCO AVENUE, PASIG CITY</p>	DRAWN BY : CAMILLE ANN C. RAPOSA CAD OPERATOR EFD-DepED	CHECKED BY : JASON ALMOITE R2/CAR PMO MANAGER EFD-DepED	RECOMMENDING APPROVAL : LUIS G. PURISIMA, JR. ASST. CHIEF, EFD-AS DepED	RECOMMENDING APPROVAL : ANNABELLE R. PANGAN CHIEF OFFICE OF THE CHIEF, EFD-AS	APPROVED BY : ALAIN VEL. B. PASCUA UNDERSECRETARY FOR ADMINISTRATION	PROJECT TITLE : REPAIR/REHABILITATION/RESTORATION OF RECTO HALL LOCATION :	PROJECT CODE :	OWNER : DEPARTMENT OF EDUCATION DepED SHEET CONTENTS : - RIGHT SIDE ELEV. - LEFT SIDE ELEV.	SHEET NO : A-5 9

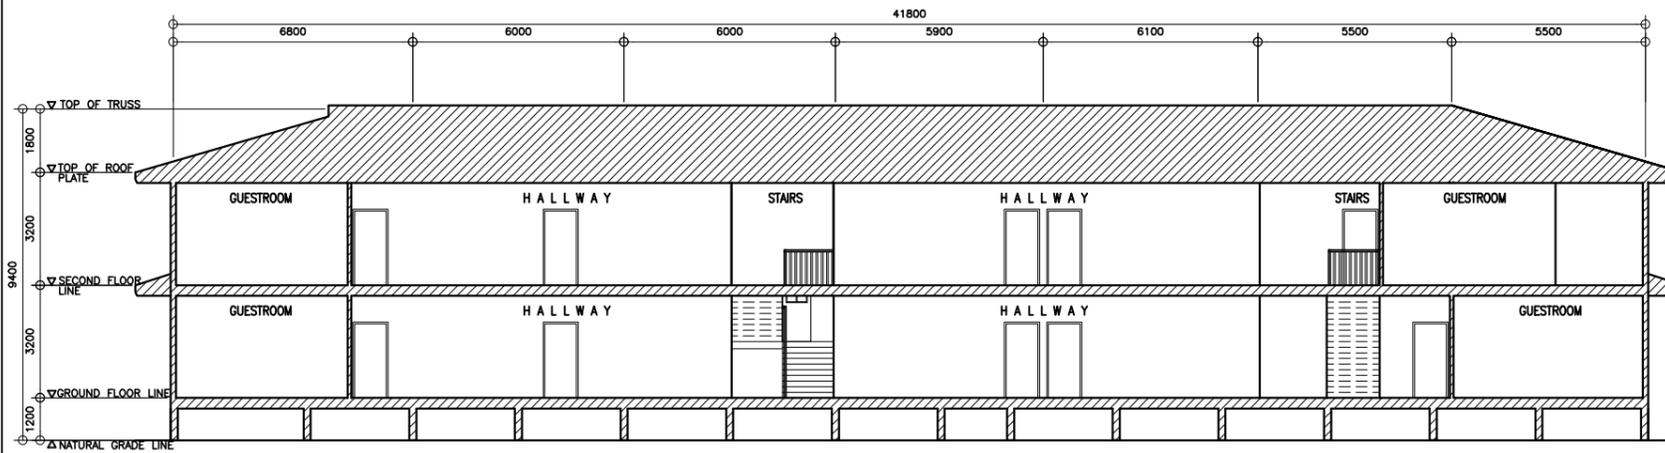


1 LONGITUDINAL SECTION
A-6 SCALE 1:200M

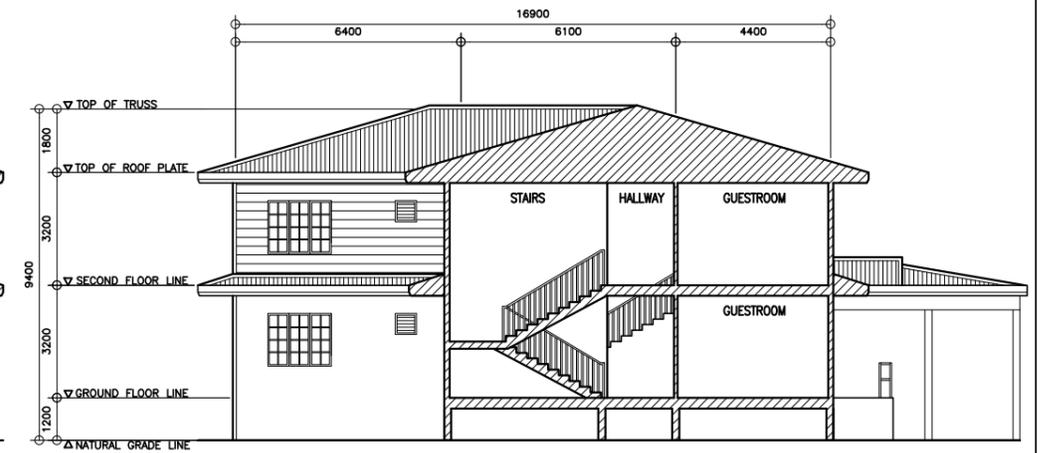


2 CROSS SECTION
A-6 SCALE 1:200M

 REPUBLIC OF THE PHILIPPINES  DEPARTMENT OF EDUCATION EDUCATION FACILITIES DIVISION MERALCO AVENUE, PASIG CITY	DRAWN BY :  CAMILLE ANN C. RAPOSA CAD OPERATOR EFD-DepED	CHECKED BY :  JASON ALMOITE R2/CAR PMO MANAGER EFD-DepED	RECOMMENDING APPROVAL :  LUIS G. PURISIMA, JR. ASST. CHIEF, EFD-AS DepED	RECOMMENDING APPROVAL :  ANNABELLE R. HANGAN CHIEF OFFICE OF THE CHIEF, EFD-AS	APPROVED BY :  ALAIN VEL. B. PASCUA UNDERSECRETARY FOR ADMINISTRATION	PROJECT TITLE : REPAIR/REHABILITATION/RESTORATION OF RECTO HALL LOCATION :	PROJECT CODE :	OWNER : DEPARTMENT OF EDUCATION DepED SHEET CONTENTS : - LONGITUDINAL SECTION - CROSS SECTION	SHEET NO : 

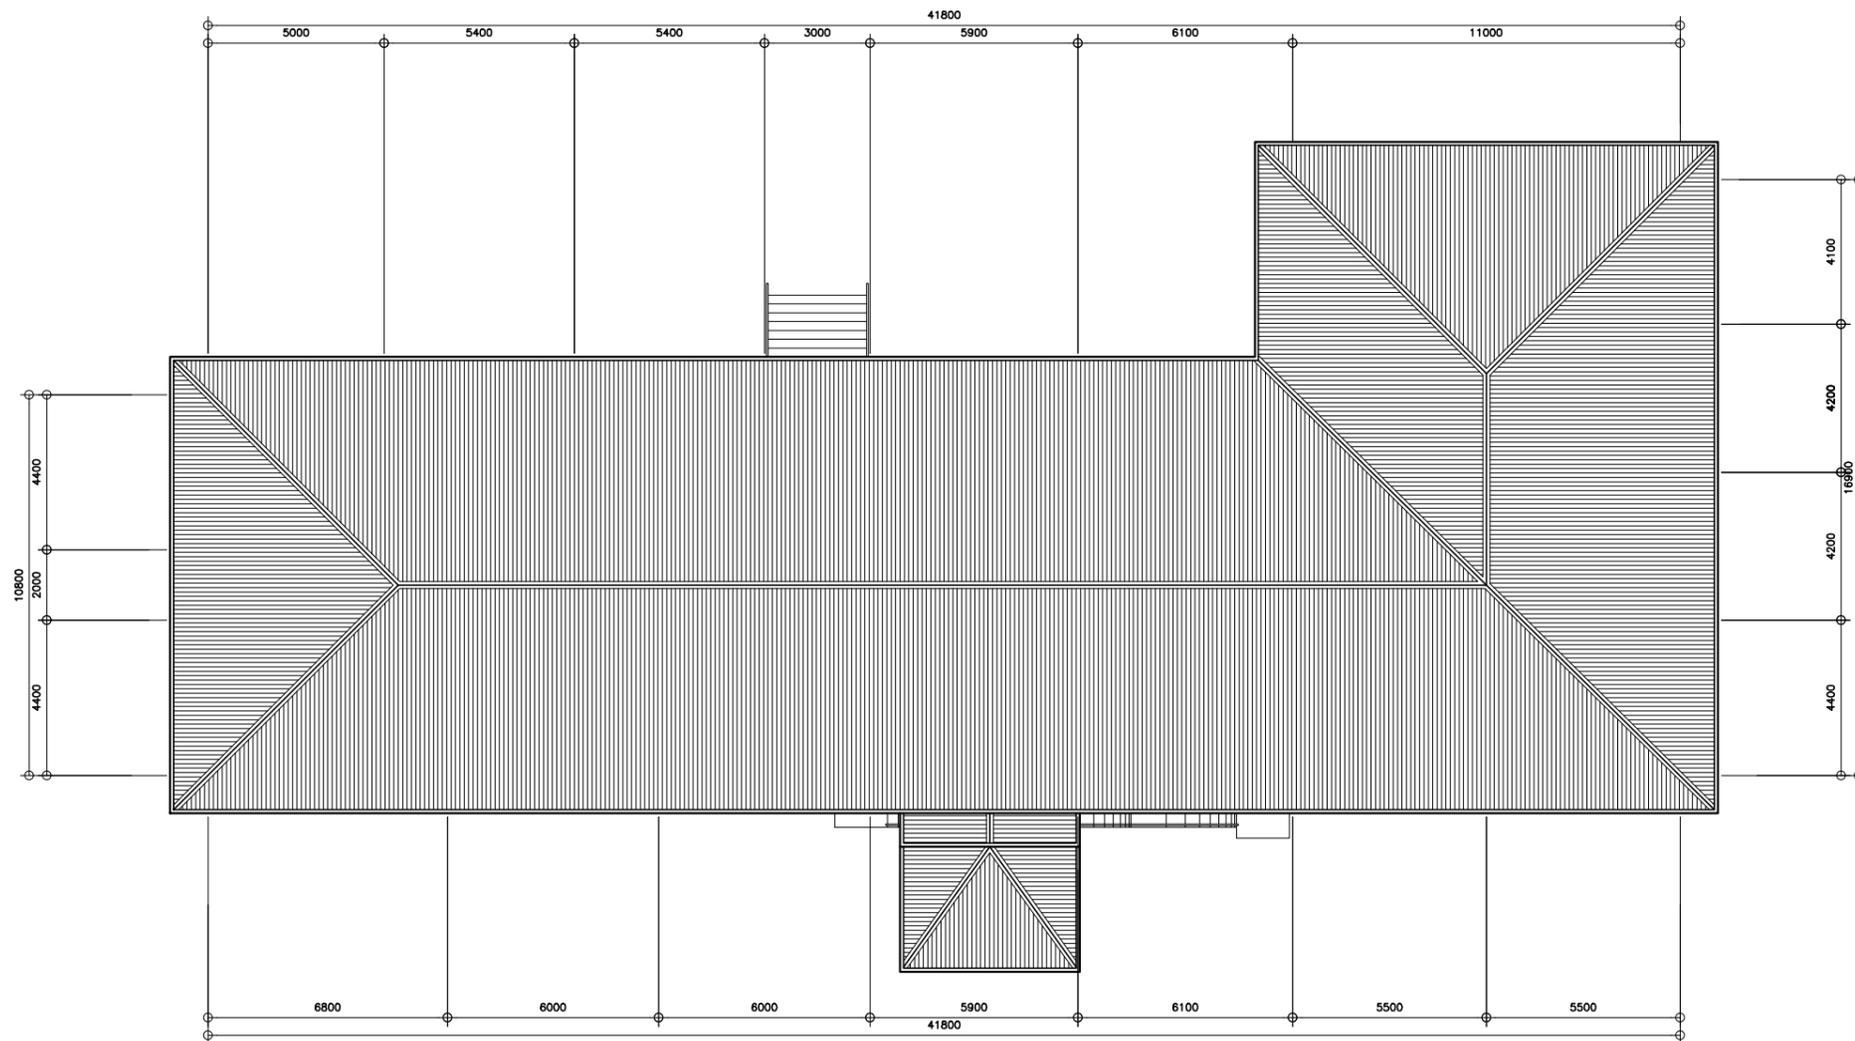


1
ROOF PLAN
A-7
SCALE
1:200M

REPUBLIC OF THE PHILIPPINES DEPARTMENT OF EDUCATION EDUCATION FACILITIES DIVISION MERALCO AVENUE, PASIG CITY	DRAWN BY :	CHECKED BY :	RECOMMENDING APPROVAL :	RECOMMENDING APPROVAL :	APPROVED BY :	PROJECT TITLE :	PROJECT CODE :	OWNER :	SHEET NO.:
	 CAMILLE ANN C. RAPOSA <small>CAD OPERATOR EFD-DepED</small>	 JASON ALMOITE <small>RZ/CAR PMO MANAGER EFD-DepED</small>	 LUIS G. PURISIMA, JR. <small>ASST. CHIEF, EFD-AS DepED</small>	 ANNABELLE R. PANGAN <small>CHIEF OFFICE OF THE CHIEF, EFD-AS</small>	 ALAIN VEL. B. PASCUA <small>UNDERSECRETARY FOR ADMINISTRATION</small>	REPAIR/REHABILITATION/RESTORATION OF RECTO HALL <small>LOCATION :</small>			DEPARTMENT OF EDUCATION DepED <small>SHEET CONTENTS : - ROOF PLAN</small>

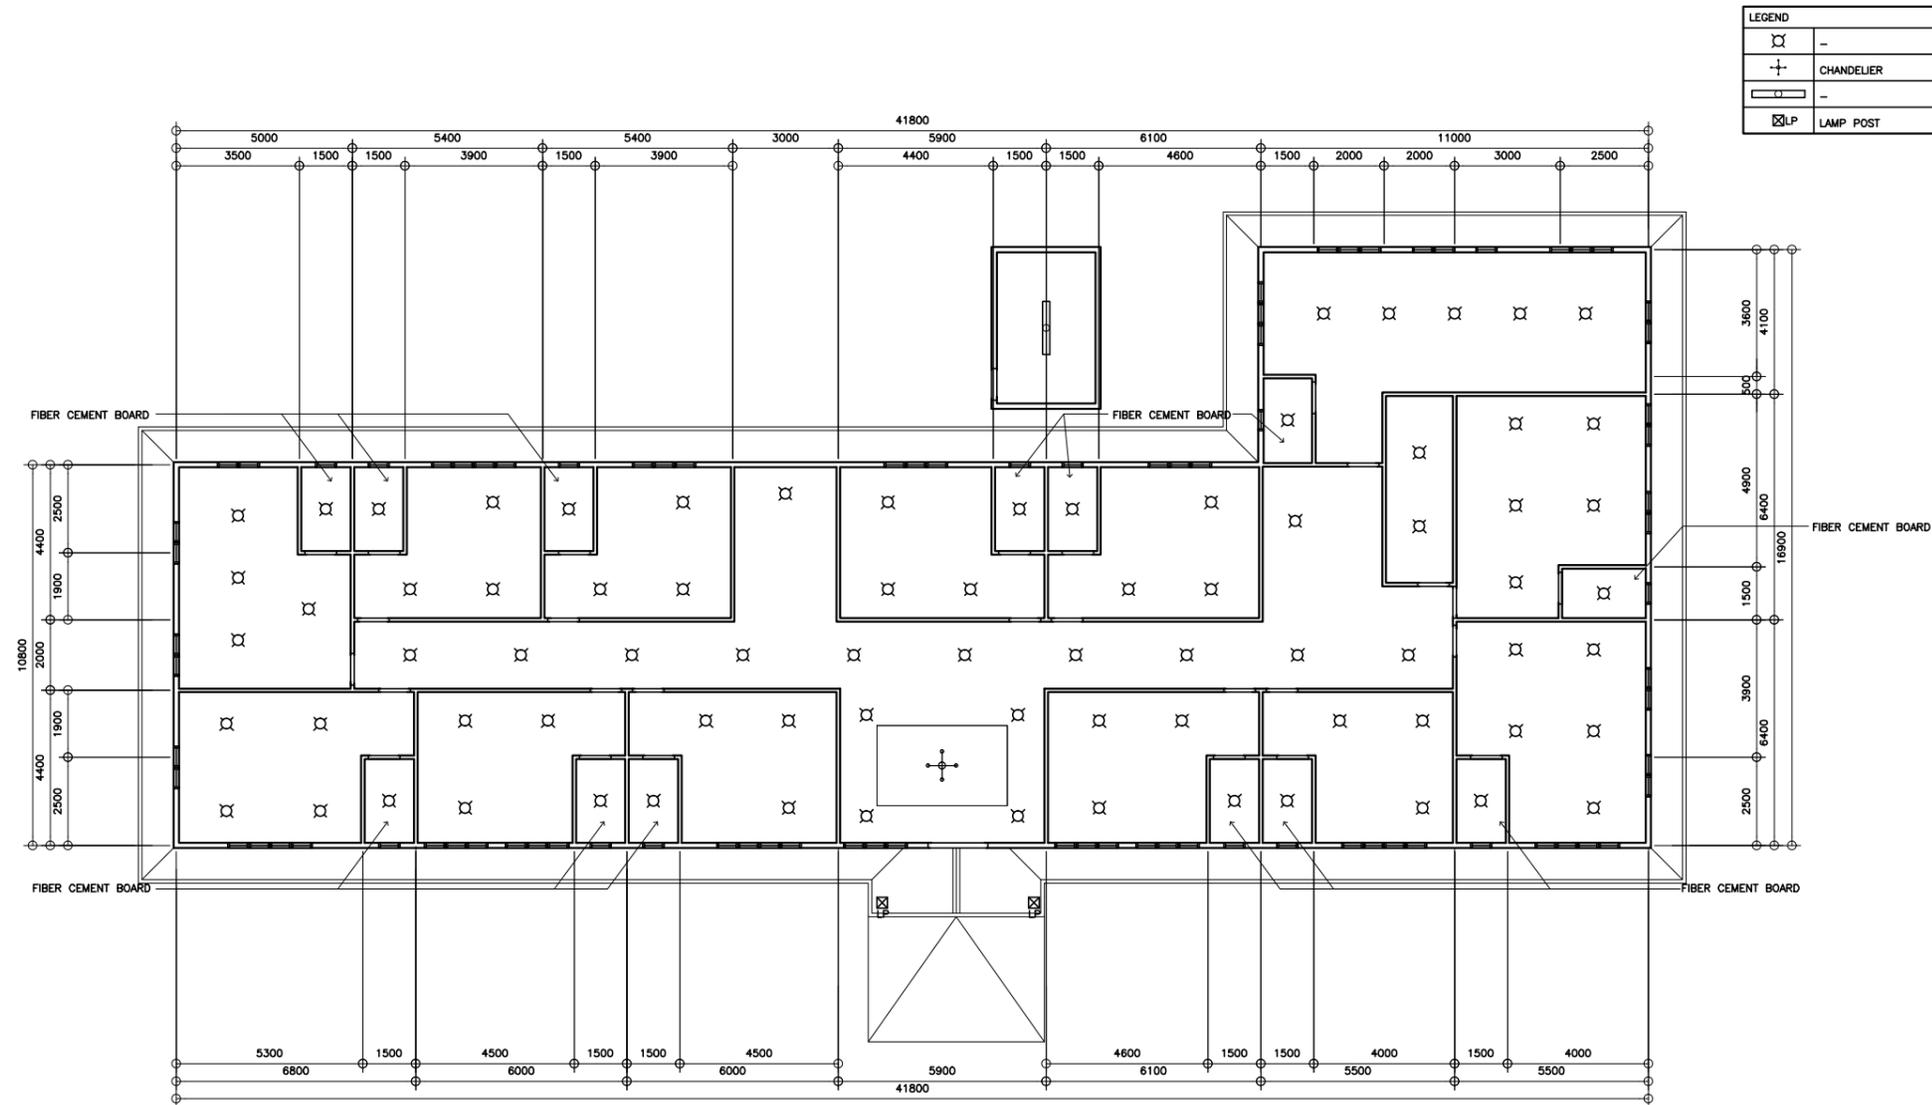


1
GROUND FLOOR REFLECTED CEILING PLAN
A-8
SCALE
1:100M

 REPUBLIC OF THE PHILIPPINES DepED DEPARTMENT OF EDUCATION EDUCATION FACILITIES DIVISION MERALCO AVENUE, PASIG CITY	DRAWN BY :	CHECKED BY :	RECOMMENDING APPROVAL :	RECOMMENDING APPROVAL :	APPROVED BY :	PROJECT TITLE :	PROJECT CODE :	OWNER :	SHEET NO.:
	 CAMILLE ANN C. RAPOSA CAD OPERATOR EFD-DepED	 JASON ALMOITE R2/CAR PMO MANAGER EFD-DepED	 LUIS G. PURISIMA, JR. ASST. CHIEF, EFD-AS DepED	 ANNABELLE R. PANGAN CHIEF OFFICE OF THE CHIEF, EFD-AS	 ALAIN VEL. B. PASCUA UNDERSECRETARY FOR ADMINISTRATION	REPAIR/REHABILITATION/RESTORATION OF RECTO HALL LOCATION :		DEPARTMENT OF EDUCATION DepED SHEET CONTENTS : - GF REFLECTED CEILING PLAN	A-8 9

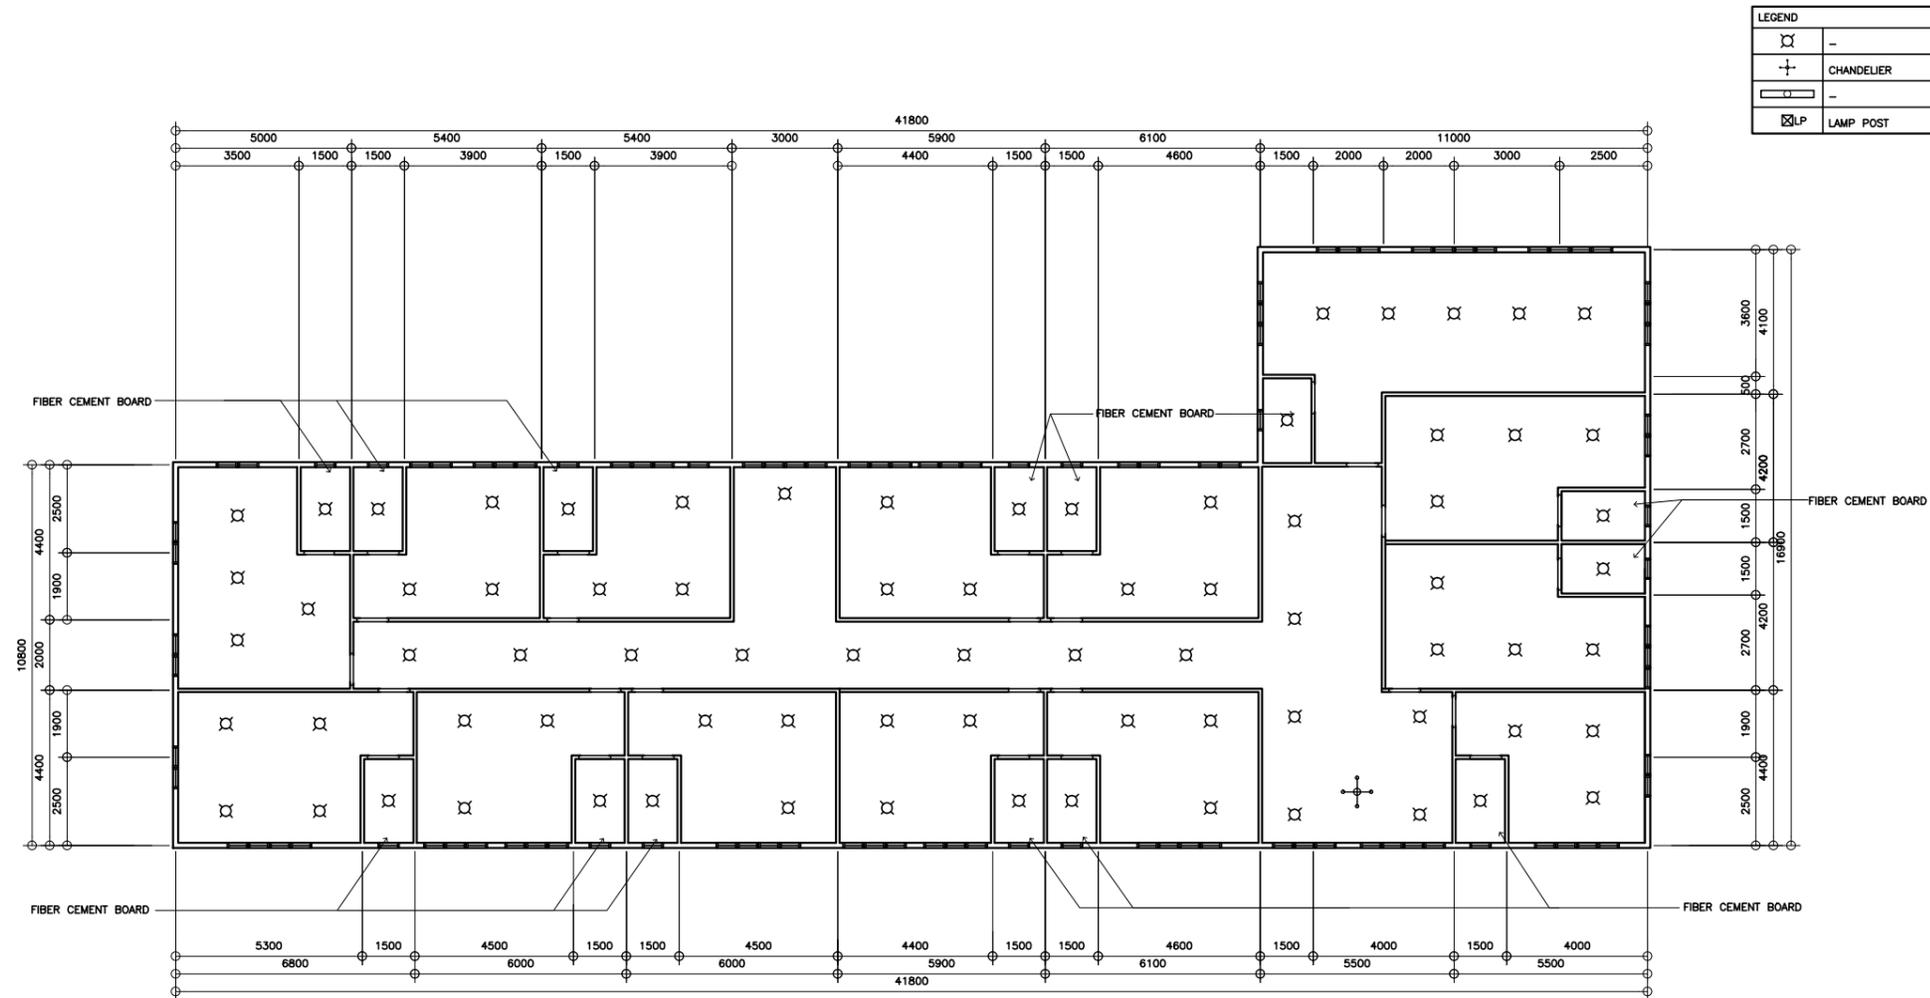

1
SECOND FLOOR REFLECTED CEILING PLAN
A-4
SCALE
1:100M


REPUBLIC OF THE PHILIPPINES DEPARTMENT OF EDUCATION EDUCATION FACILITIES DIVISION MERALCO AVENUE, PASIG CITY	DRAWN BY : CAMILLE ANN C. RAPOSA CAD OPERATOR EFD-DepED	CHECKED BY : JASON ALMOITE R2/CAR PMO MANAGER EFD-DepED	RECOMMENDING APPROVAL : LUIS G. PURISIMA, JR. ASST. CHIEF, EFD-AS DepED	RECOMMENDING APPROVAL : ANNABELLE R. HANGAN CHIEF OFFICE OF THE CHIEF, EFD-AS	APPROVED BY : ALAIN VEL. B. PASCUA UNDERSECRETARY FOR ADMINISTRATION	PROJECT TITLE : REPAIR/REHABILITATION/RESTORATION OF RECTO HALL LOCATION :	PROJECT CODE :	OWNER : DEPARTMENT OF EDUCATION DepED SHEET CONTENTS : - 2F REFLECTED CEILING PLAN	SHEET NO : <div style="border: 1px solid black; border-radius: 50%; width: 40px; height: 40px; display: flex; align-items: center; justify-content: center; margin: 0 auto;"> A-9 9 </div>
---	--	--	--	--	---	--	----------------	--	--

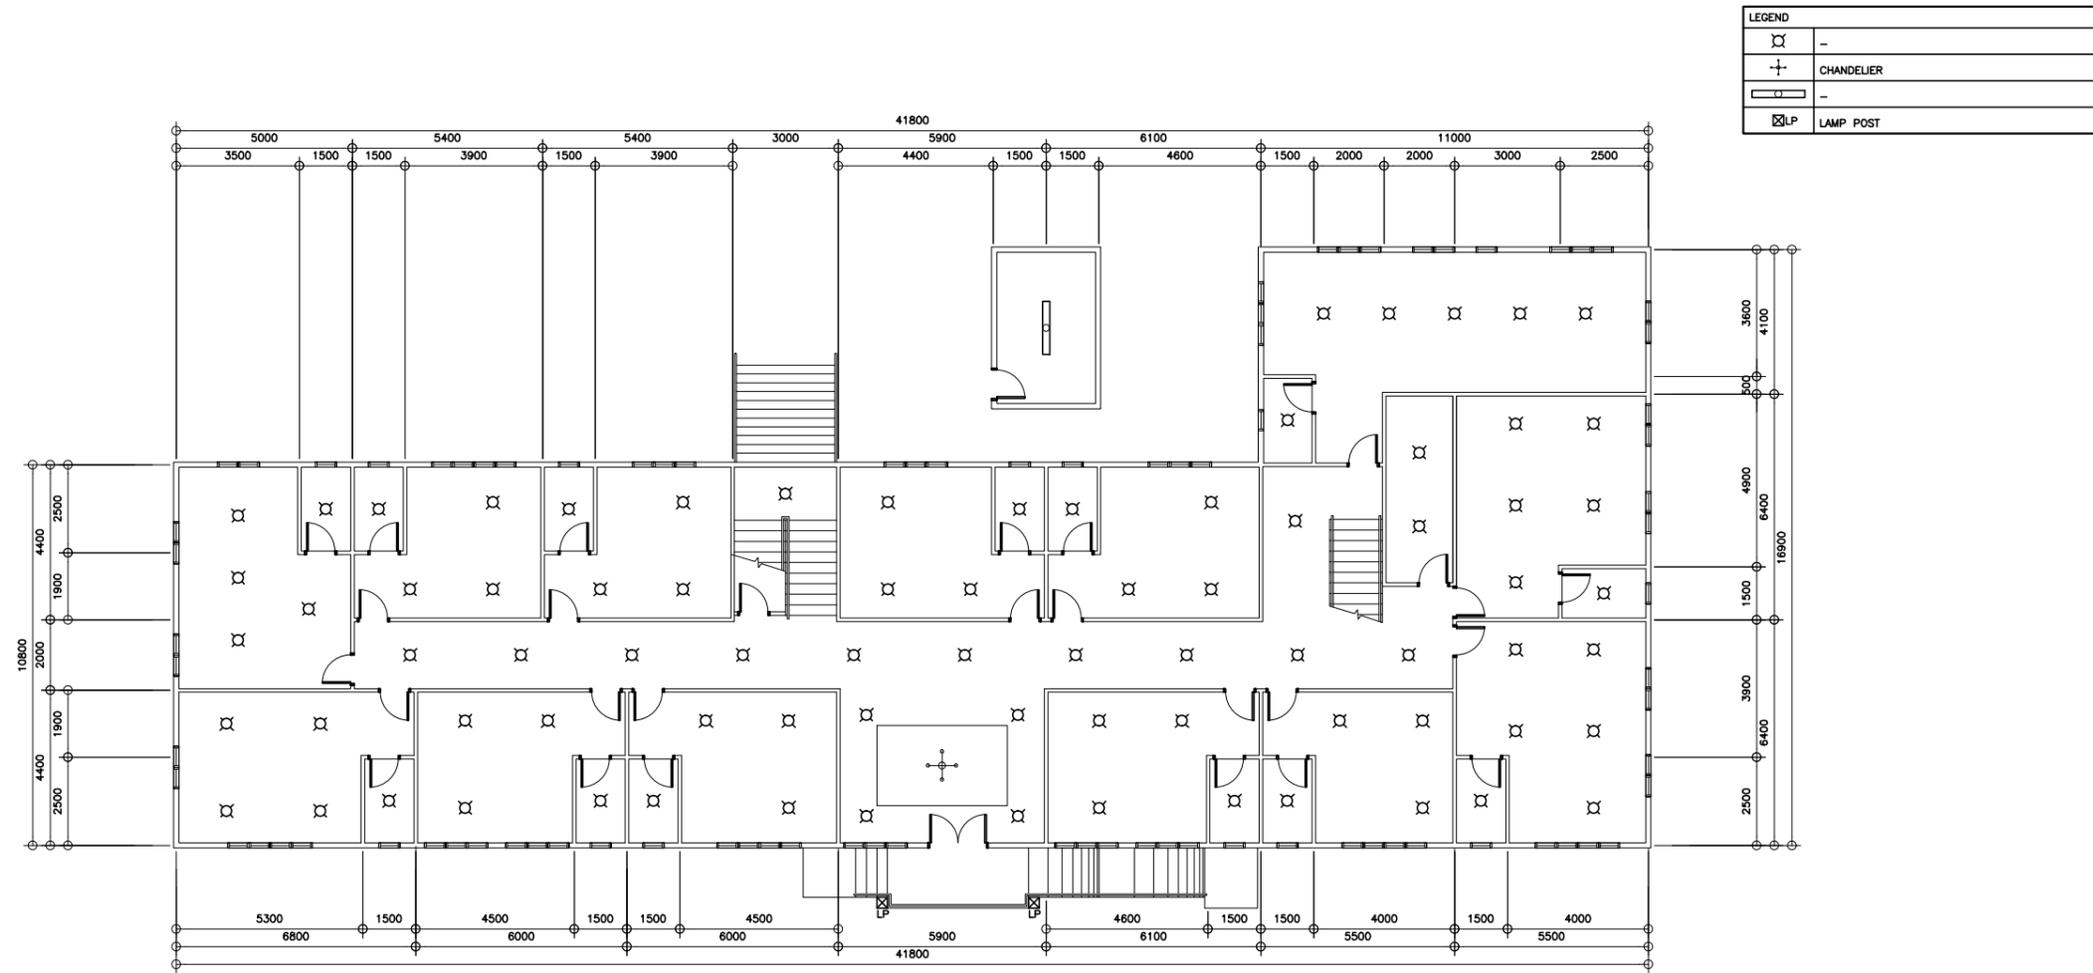

1
E-1

GROUND FLOOR LIGHTING LAYOUT
 SCALE 1:100M

REPUBLIC OF THE PHILIPPINES DEPARTMENT OF EDUCATION EDUCATION FACILITIES DIVISION MERALCO AVENUE, PASIG CITY	DRAWN BY : CAMILLE ANN C. RAPOSA CAD OPERATOR EFD-DepED	CHECKED BY : JASON ALMOITE R2/CAR PMO MANAGER EFD-DepED	RECOMMENDING APPROVAL : LUIS G. PURISIMA, JR. ASST. CHIEF, EFD-AS DepED	RECOMMENDING APPROVAL : ANNABELLE R. HANGAN CHIEF OFFICE OF THE CHIEF, EFD-AS	APPROVED BY : ALAIN VEL. B. PASCUA UNDERSECRETARY FOR ADMINISTRATION	PROJECT TITLE : REPAIR/REHABILITATION/RESTORATION OF RECTO HALL LOCATION :	PROJECT CODE :	OWNER : DEPARTMENT OF EDUCATION DepED SHEET CONTENTS : - GROUND FLOOR LIGHTING LAYOUT	SHEET NO: E-1 8
---	--	--	--	--	---	---	----------------	---	---

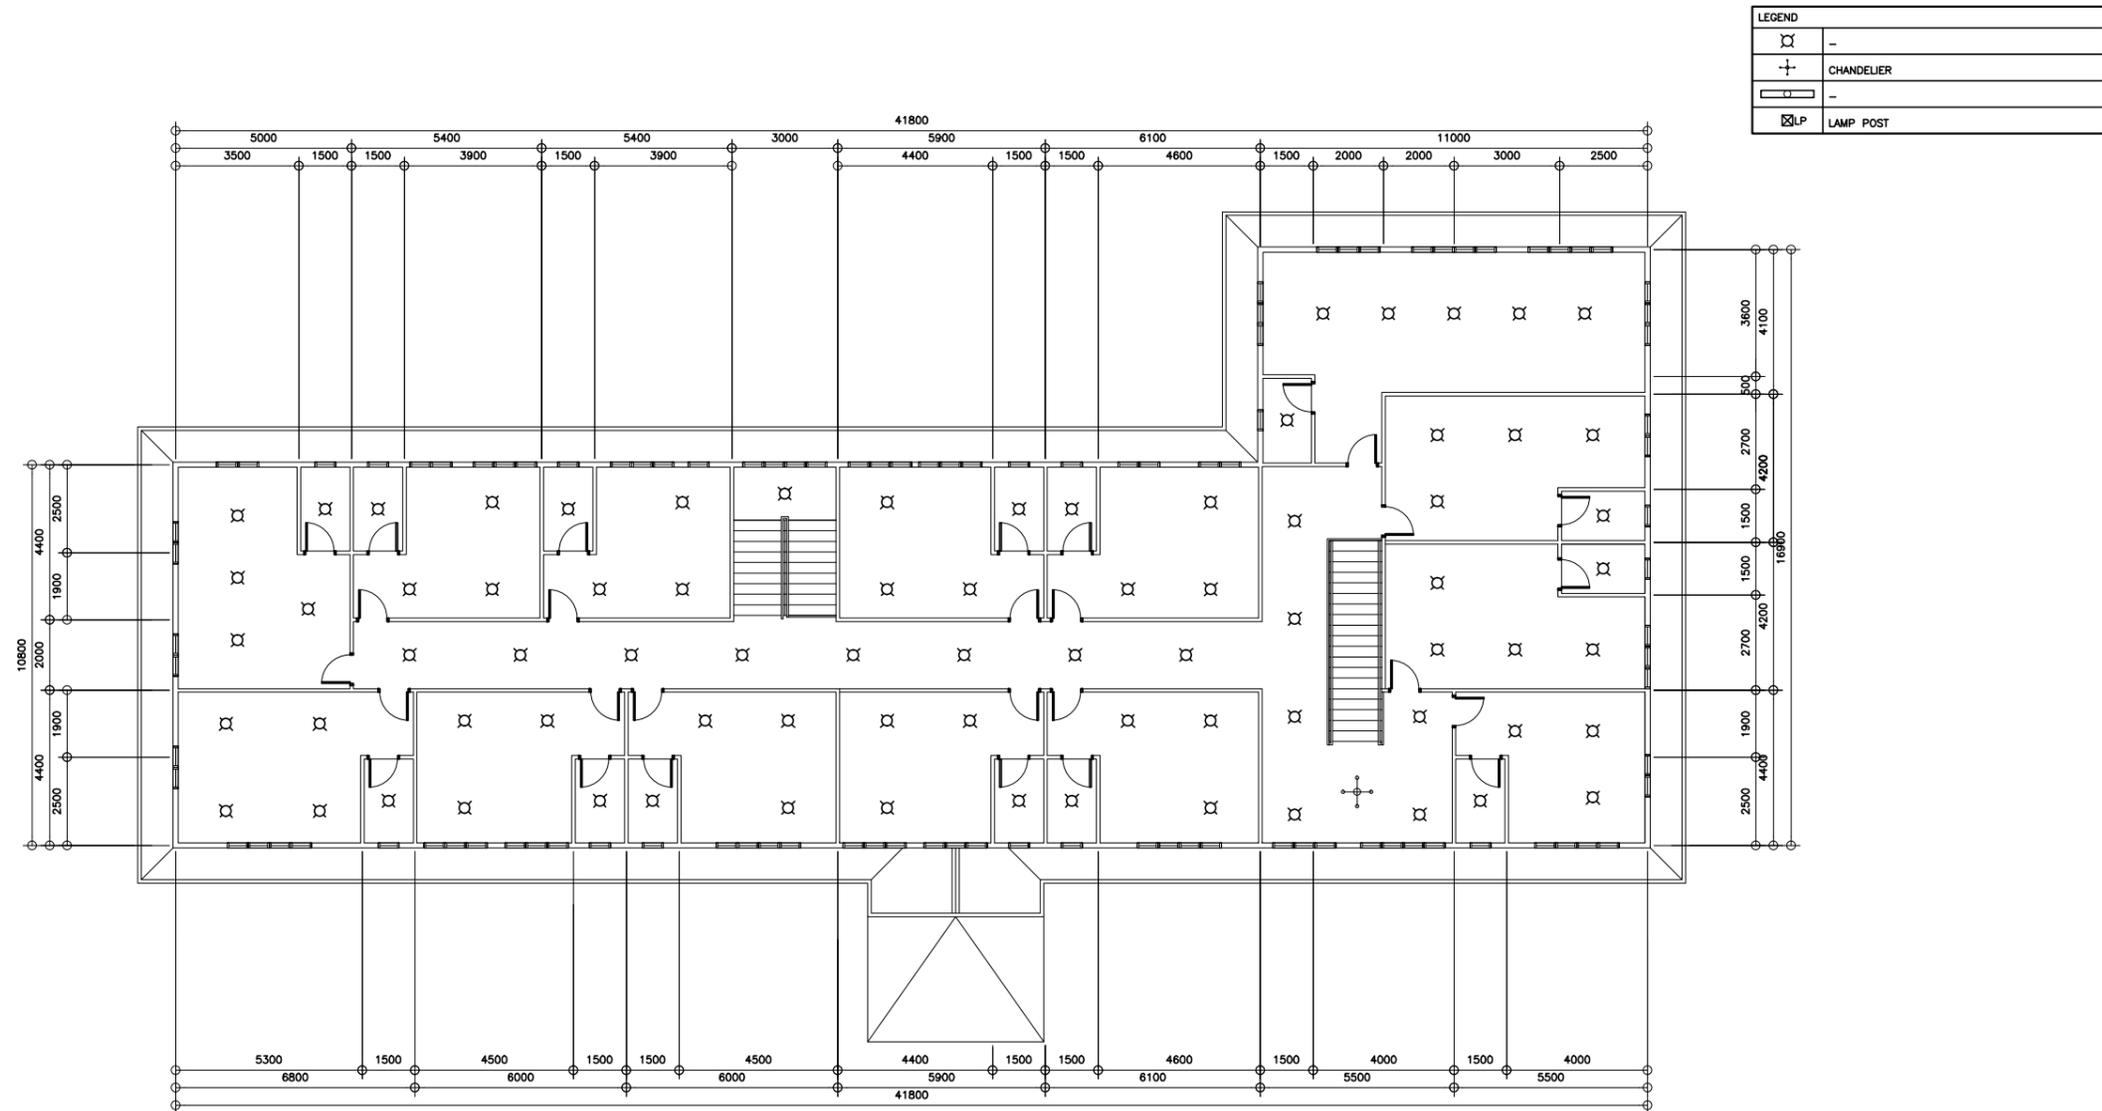


1
E-2

SECOND FLOOR LIGHTING LAYOUT
 SCALE 1:100M


REPUBLIC OF THE PHILIPPINES  DEPARTMENT OF EDUCATION EDUCATION FACILITIES DIVISION MERALCO AVENUE, PASIG CITY	DRAWN BY :  CAMILLE ANN C. RAPOSA CAD OPERATOR EFD-DepED	CHECKED BY :  JASON ALMOITE R2/CAR PMO MANAGER EFD-DepED	RECOMMENDING APPROVAL :  LUIS G. PURISIMA, JR. ASST. CHIEF, EFD-AS DepED	RECOMMENDING APPROVAL :  ANNABELLE R. PANGAN CHIEF OFFICE OF THE CHIEF, EFD-AS	APPROVED BY :  ALAIN VEL. B. PASCUA UNDERSECRETARY FOR ADMINISTRATION	PROJECT TITLE : REPAIR/REHABILITATION/RESTORATION OF RECTO HALL LOCATION :	PROJECT CODE :	OWNER : DEPARTMENT OF EDUCATION DepED SHEET CONTENTS : - SECOND FLOOR LIGHTING LAYOUT	SHEET NO: E-2 8
--	---	---	---	---	--	---	----------------	---	--

LEGEND	
	DUPLEX CONVENIENCE OUTLET
	WEATHERPROOF DUPLEX CONVENIENCE OUTLET
	PANELBOARD

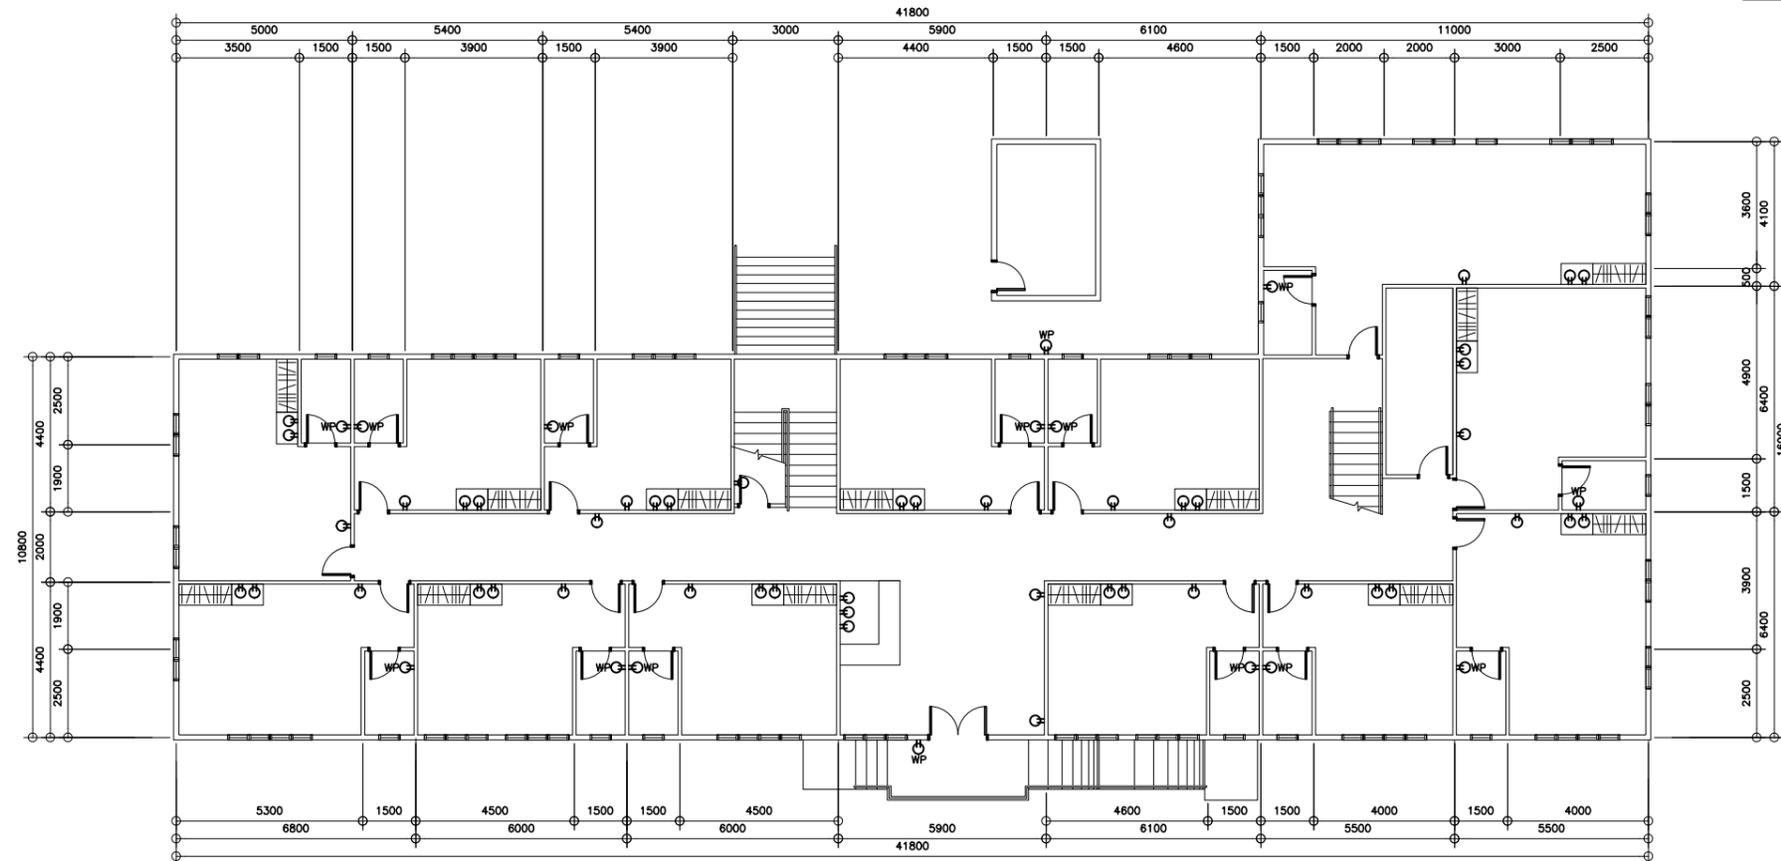

1
GROUND FLOOR POWER LAYOUT
E-3
 SCALE 1:100M


REPUBLIC OF THE PHILIPPINES DEPARTMENT OF EDUCATION EDUCATION FACILITIES DIVISION MERALCO AVENUE, PASIG CITY	DRAWN BY : CAMILLE ANN C. RAPOSA CAD OPERATOR EFD-DepED	CHECKED BY : JASON ALMOITE R2/CAR PMO MANAGER EFD-DepED	RECOMMENDING APPROVAL : LUIS G. PURISIMA, JR. ASST. CHIEF, EFD-AS DepED	RECOMMENDING APPROVAL : ANNABELLE R. PANGAN CHIEF OFFICE OF THE CHIEF, EFD-AS	APPROVED BY : ALAIN VEL. B. PASCUA UNDERSECRETARY FOR ADMINISTRATION	PROJECT TITLE : REPAIR/REHABILITATION/RESTORATION OF RECTO HALL LOCATION :	PROJECT CODE :	OWNER : DEPARTMENT OF EDUCATION DepED SHEET CONTENTS : - GROUND FLOOR POWER LAYOUT	SHEET NO: E-3 8
---	--	--	--	--	---	--	----------------	---	---

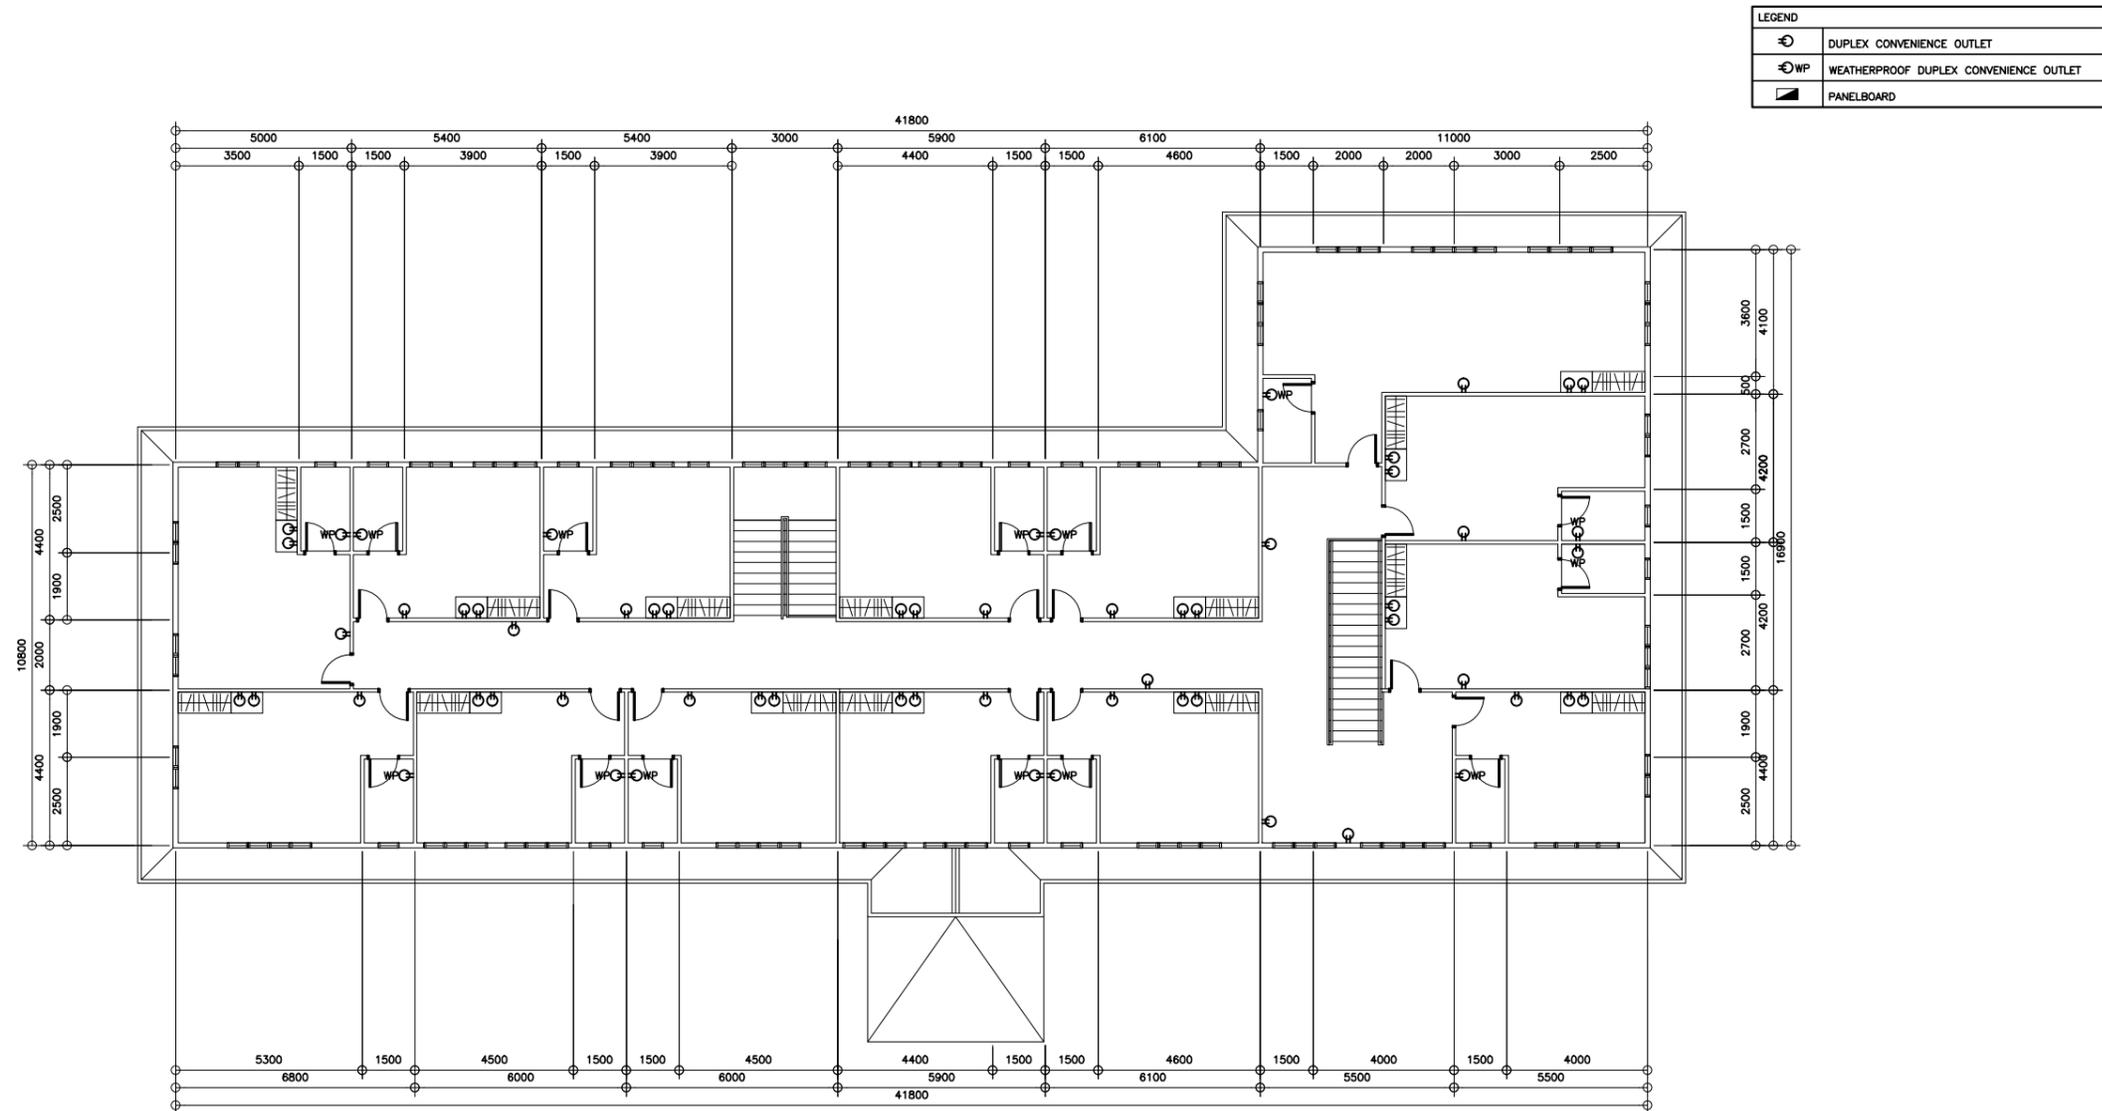

1
SECOND FLOOR POWER LAYOUT
E-4
SCALE
1:100M

 REPUBLIC OF THE PHILIPPINES DepED DEPARTMENT OF EDUCATION EDUCATION FACILITIES DIVISION MERALCO AVENUE, PASIG CITY	DRAWN BY :	CHECKED BY :	RECOMMENDING APPROVAL :	RECOMMENDING APPROVAL :	APPROVED BY :	PROJECT TITLE :	PROJECT CODE :	OWNER :	SHEET NO.:
	 CAMILLE ANN C. RAPOSA CAD OPERATOR EFD-DepED	 JASON ALMOITE R2/CAR PMO MANAGER EFD-DepED	 LUIS G. PURISIMA, JR. ASST. CHIEF, EFD-AS DepED	 ANNABELLE R. PANGAN CHIEF OFFICE OF THE CHIEF, EFD-AS	 ALAIN VEL. B. PASCUA UNDERSECRETARY FOR ADMINISTRATION	REPAIR/REHABILITATION/RESTORATION OF RECTO HALL LOCATION :		DEPARTMENT OF EDUCATION DepED SHEET CONTENTS : - SECOND FLOOR POWER LAYOUT	E-4 8


LEGEND	
⊕	-
□	-

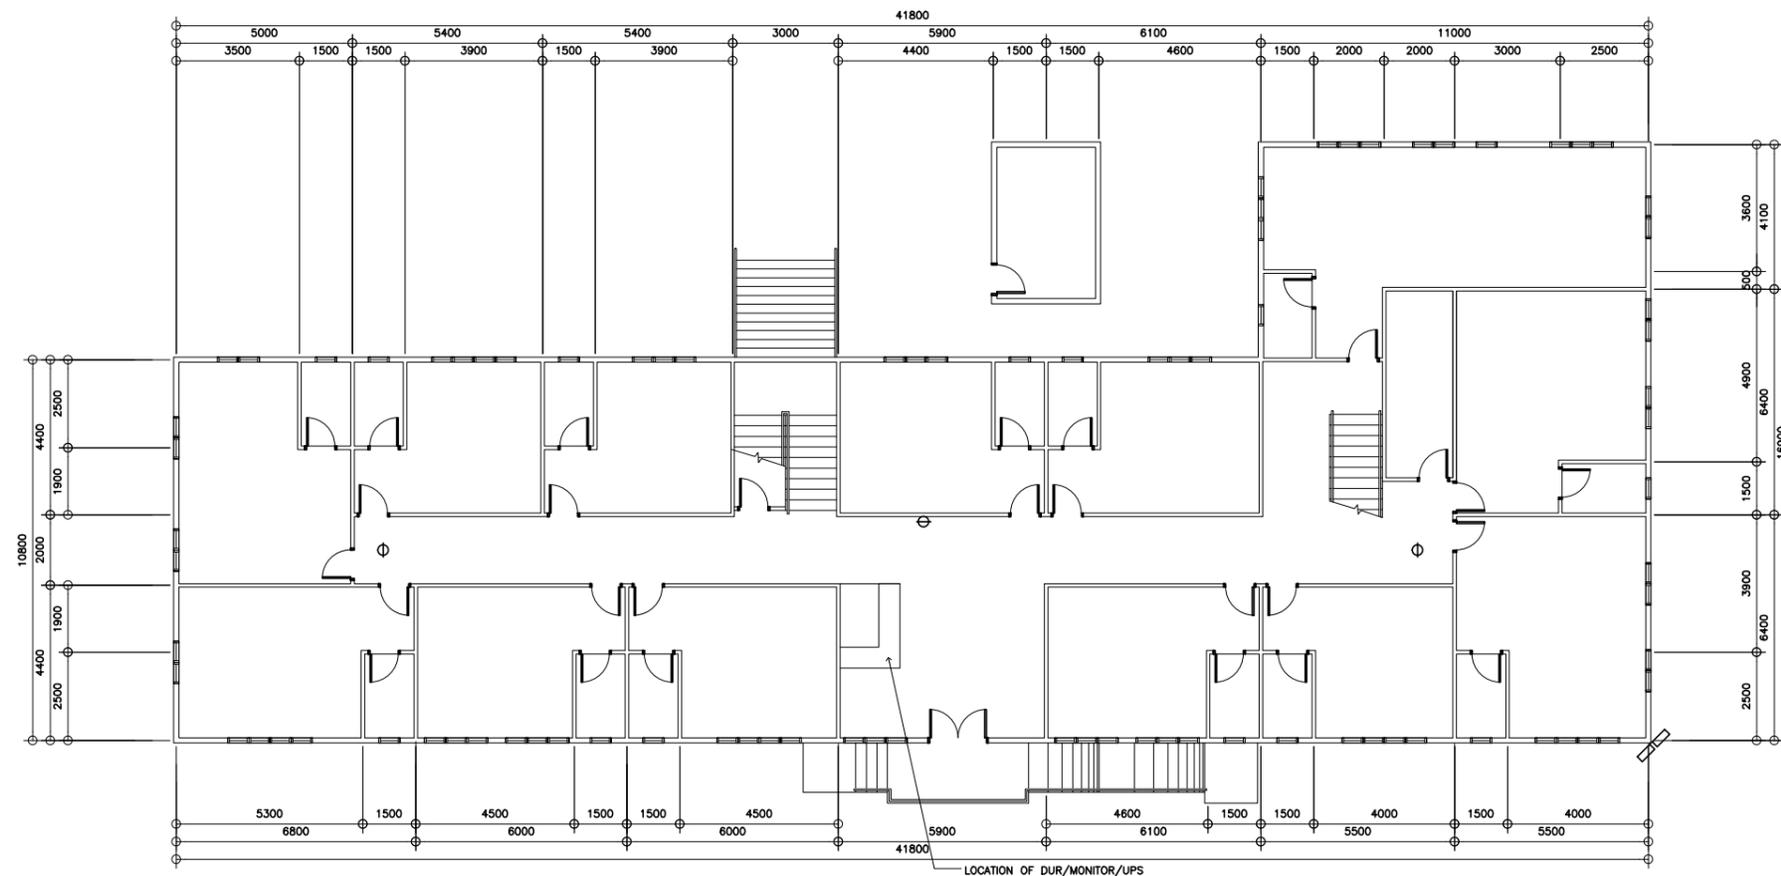

1
GROUND FLOOR CCTV LAYOUT
E-5
SCALE
1:100M


 REPUBLIC OF THE PHILIPPINES DepED DEPARTMENT OF EDUCATION EDUCATION FACILITIES DIVISION MERALCO AVENUE, PASIG CITY	DRAWN BY :	CHECKED BY :	RECOMMENDING APPROVAL :	RECOMMENDING APPROVAL :	APPROVED BY :	PROJECT TITLE :	PROJECT CODE :	OWNER :	SHEET NO.:
	 CAMILLE ANN C. RAPOSA CAD OPERATOR EFD-DepED	 JASON ALMOITE R2/CAR PMO MANAGER EFD-DepED	 LUIS G. PURISIMA, JR. ASST. CHIEF, EFD-AS DepED	 ANNABELLE R. HANGAN CHIEF OFFICE OF THE CHIEF, EFD-AS	 ALAIN VEL. B. PASCUA UNDERSECRETARY FOR ADMINISTRATION	REPAIR/REHABILITATION/RESTORATION OF RECTO HALL LOCATION :		DEPARTMENT OF EDUCATION DepED SHEET CONTENTS : - GROUND FLOOR CCTV LAYOUT	E-5 8

LEGEND	
⊕	-
□	-

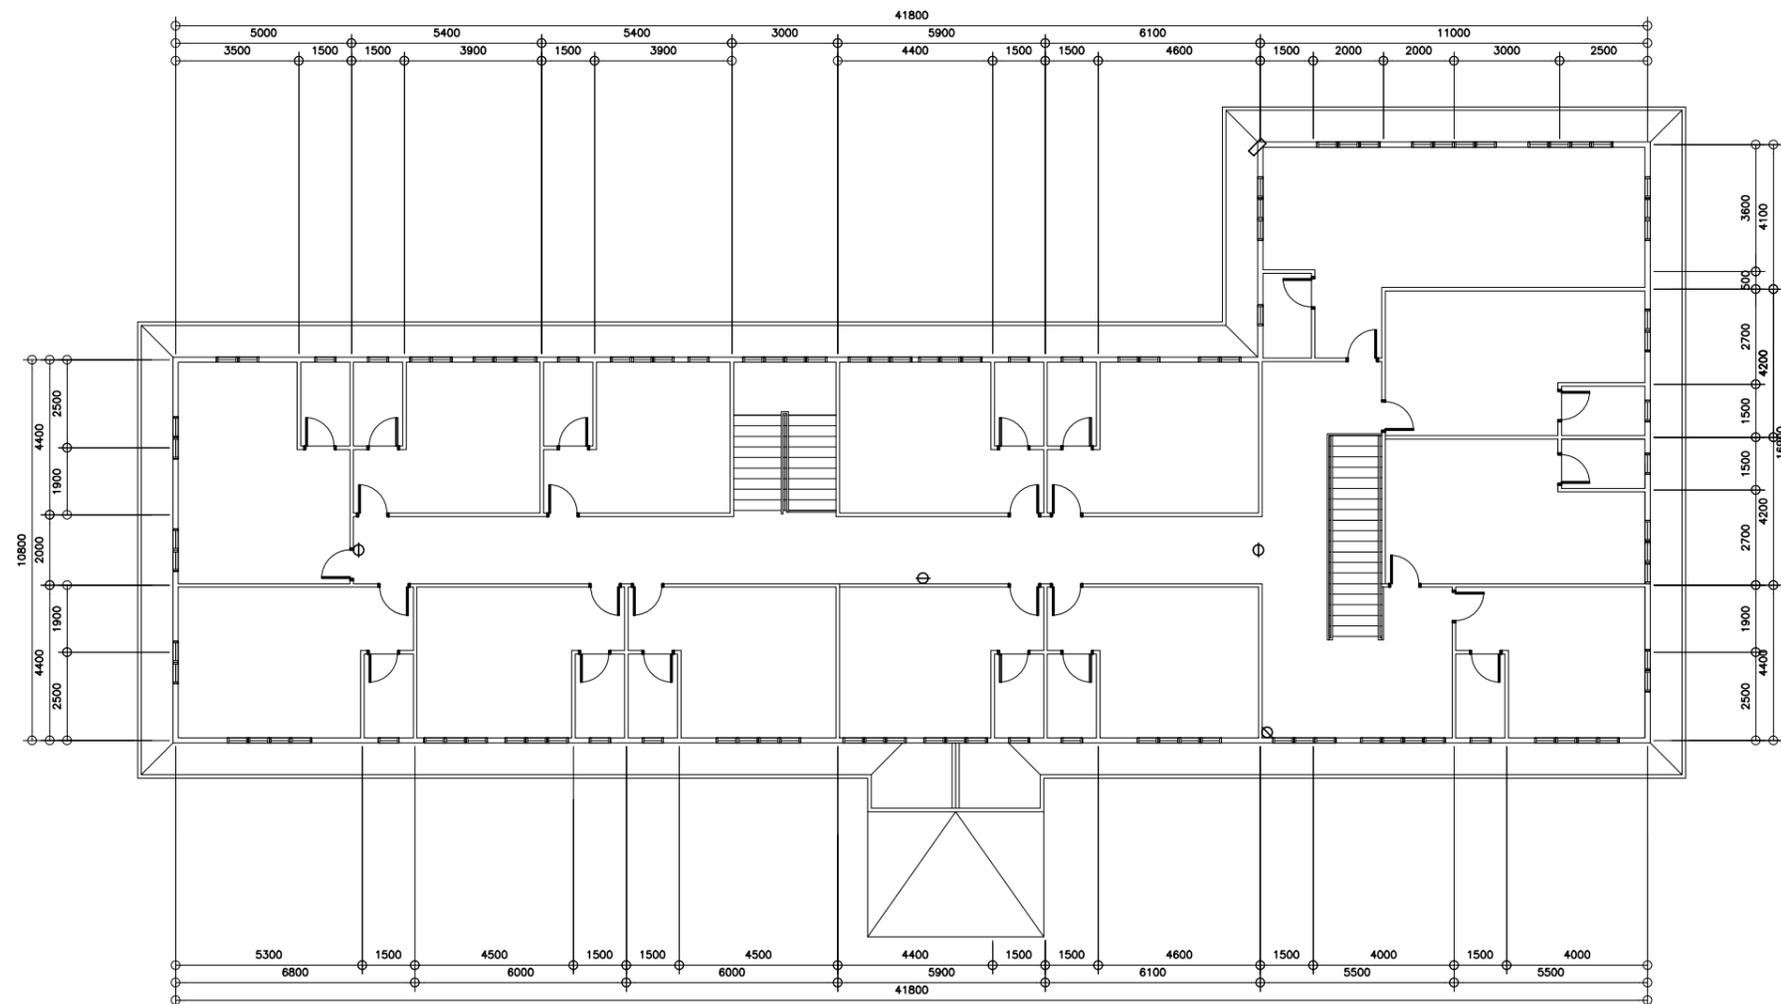

1
SECOND FLOOR CCTV LAYOUT
E-6
SCALE
1:100M


REPUBLIC OF THE PHILIPPINES DEPARTMENT OF EDUCATION EDUCATION FACILITIES DIVISION MERALCO AVENUE, PASIG CITY	DRAWN BY : CAMILLE ANN C. RAPOSA CAD OPERATOR EFD-DepED	CHECKED BY : JASON ALMOITE R2/CAR PMO MANAGER EFD-DepED	RECOMMENDING APPROVAL : LUIS G. PURISIMA, JR. ASST. CHIEF, EFD-AS DepED	RECOMMENDING APPROVAL : ANNABELLE R. PANGAN CHIEF OFFICE OF THE CHIEF, EFD-AS	APPROVED BY : ALAIN VEL. B. PASCUA UNDERSECRETARY FOR ADMINISTRATION	PROJECT TITLE : REPAIR/REHABILITATION/RESTORATION OF RECTO HALL LOCATION :	PROJECT CODE :	OWNER : DEPARTMENT OF EDUCATION DepED SHEET CONTENTS : - SECOND FLOOR CCTV LAYOUT	SHEET NO: <div style="border: 1px solid black; border-radius: 50%; width: 40px; height: 40px; display: flex; align-items: center; justify-content: center; margin: 0 auto;"> E-6 8 </div>
---	--	--	--	--	---	--	----------------	--	---

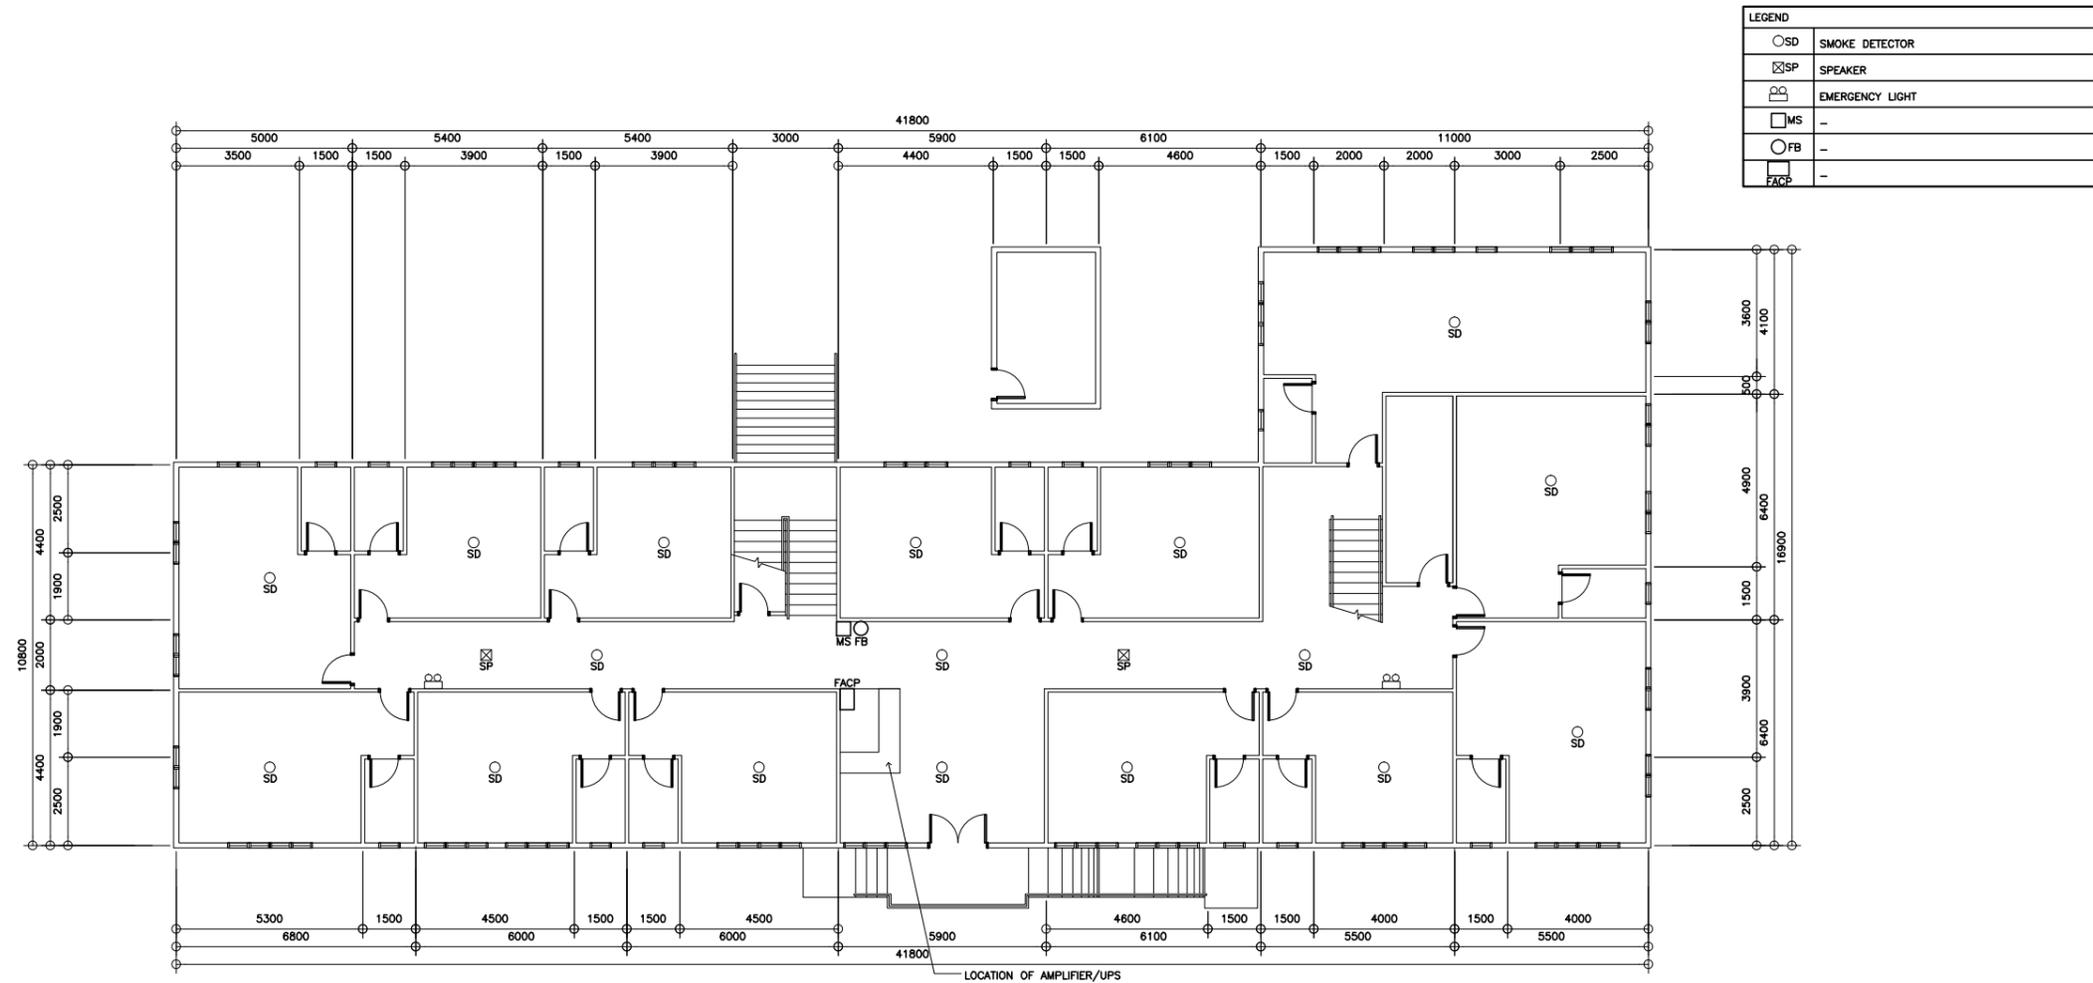

LEGEND	
○SD	SMOKE DETECTOR
⊗SP	SPEAKER
⊕EL	EMERGENCY LIGHT
□MS	-
○FB	-
□FACP	-

1
GROUND FLOOR AUDIO/FIRE LAYOUT
E-7
SCALE
1:100M

 REPUBLIC OF THE PHILIPPINES DepED DEPARTMENT OF EDUCATION EDUCATION FACILITIES DIVISION MERALCO AVENUE, PASIG CITY	DRAWN BY :	CHECKED BY :	RECOMMENDING APPROVAL :	RECOMMENDING APPROVAL :	APPROVED BY :	PROJECT TITLE :	PROJECT CODE :	OWNER :	SHEET NO.:
	 CAMILLE ANN C. RAPOSA CAD OPERATOR EFD-DepED	 JASON ALMOITE R2/CAR PMO MANAGER EFD-DepED	 LUIS G. PURISIMA, JR. ASST. CHIEF, EFD-AS DepED	 ANNABELLE R. PANGAN CHIEF OFFICE OF THE CHIEF, EFD-AS	 ALAIN VEL. B. PASCUA UNDERSECRETARY FOR ADMINISTRATION	REPAIR/REHABILITATION/RESTORATION OF RECTO HALL LOCATION :			DEPARTMENT OF EDUCATION DepED SHEET CONTENTS : - GROUND FLOOR AUDIO/FIRE LAYOUT

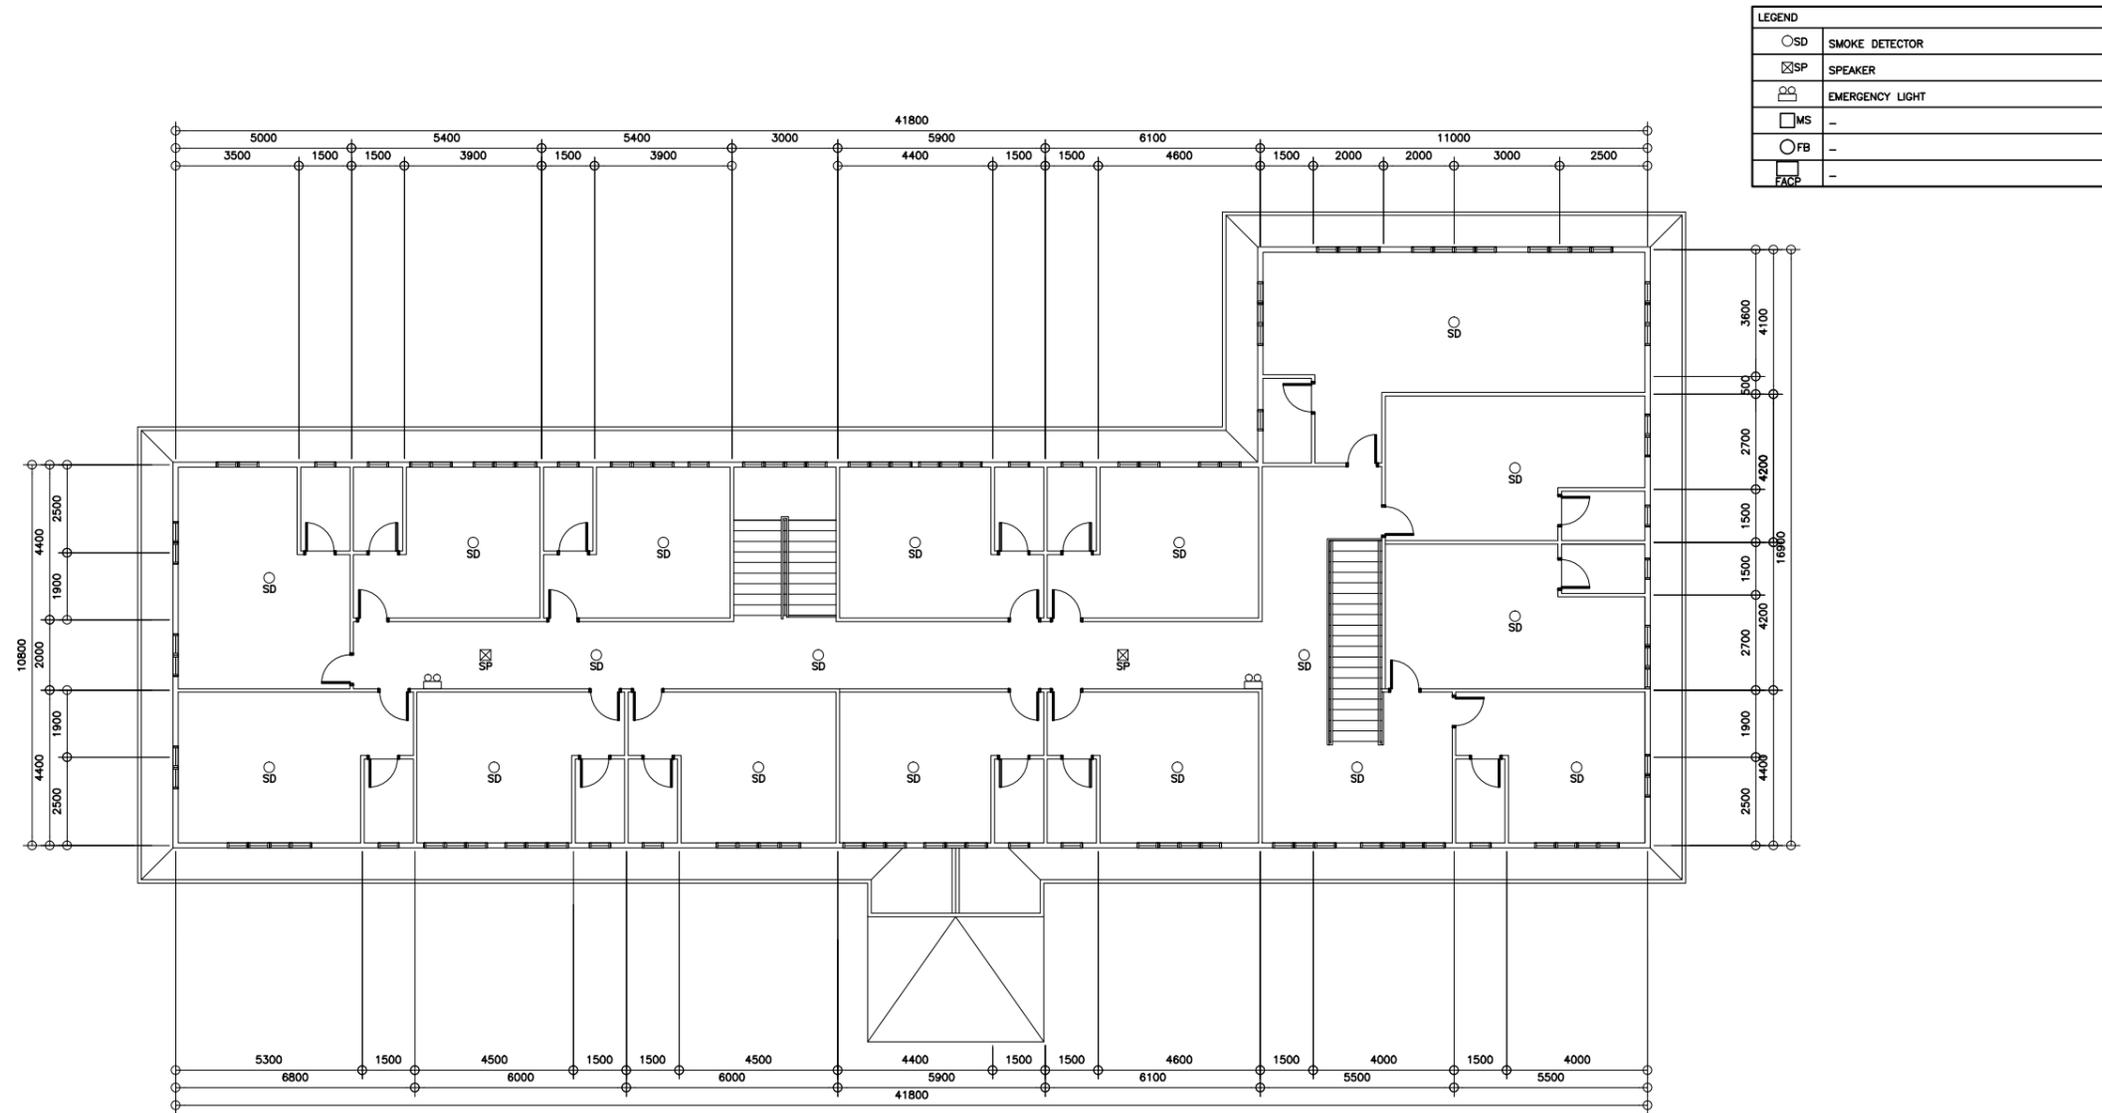

1
SECOND FLOOR AUDIO/FIRE LAYOUT
E-8
SCALE
1:100M

REPUBLIC OF THE PHILIPPINES DEPARTMENT OF EDUCATION EDUCATION FACILITIES DIVISION MERALCO AVENUE, PASIG CITY	DRAWN BY : CAMILLE ANN C. RAPOSA CAD OPERATOR EFD-DepED	CHECKED BY : JASON ALMOITE R2/CAR PMO MANAGER EFD-DepED	RECOMMENDING APPROVAL : LUIS G. PURISIMA, JR. ASST. CHIEF, EFD-AS DepED	RECOMMENDING APPROVAL : ANNABELLE R. PANGAN CHIEF OFFICE OF THE CHIEF, EFD-AS	APPROVED BY : ALAIN VEL. B. PASCUA UNDERSECRETARY FOR ADMINISTRATION	PROJECT TITLE : REPAIR/REHABILITATION/RESTORATION OF RECTO HALL LOCATION :	PROJECT CODE :	OWNER : DEPARTMENT OF EDUCATION DepED SHEET CONTENTS : - SECOND FLOOR AUDIO/FIRE LAYOUT	SHEET NO: <div style="border: 1px solid black; border-radius: 50%; width: 40px; height: 40px; display: flex; align-items: center; justify-content: center; margin: 0 auto;"> E-8 8 </div>
---	--	--	--	--	---	--	----------------	--	---